

SANITATION FIELD HEADQUARTERS NORTH AREA 1

7222 W. FOND DU LAC AVE.

ARCHITECTURAL

1. SITE PLAN & INDEX
2. FLOOR PLAN & DETAILS
3. PLANS & DETAILS
4. SECTIONS & ELEVATIONS
5. SECTIONS & DETAILS

HEATING & VENTILATING

- HV-1 CEILING PLAN & SECTIONS
- HV-2 DETAILS & SCHEDULES

PLUMBING

- P-1 SITE PLAN & DETAILS
- P-2 PLANS & SCHEMATICS

ELECTRICAL

- E-1 ELECTRICAL PLAN & DETAILS

LEGEND




- 0.00 — NEW GRADES
- - - 0.00 - - - EXISTING GRADES
- - - - - NEW CHAIN LINK FENCE
- x x x x PLANT'S (BROADMOOR JUNIPER) (JUNIPERUS SABINA "BROADMOOR") 5 GAL. (3'-0" O.C.)
- ⊙ PLANT'S (TECHNY DAKE GREEN) (THUJA OCCIDENTALIS NIGRA "TECHNY") 3'-0" - 3'-6"
- * EXIST'G. TREES
- NEW CONCRETE WORK (STOOPS, WALK, CURB, DRIVE, ETC.)
- NEW SOD

NOTE:

EXISTING FENCE TO REMAIN DURING CONSTRUCTION FOR SECURITY ALONG FOND DU LAC AVE. AND WILL BE REMOVED BY CITY AT END OF PROJECT.

REMOVE (10) EXIST'G STEEL POLES ON SITE.


REMOVE 2" ASPHALT, 2" STONE BASE & GROUND AND REPLACE WITH 10% ASPHALT & BASE AS SPECIFIED, ON SOUTH HALF OF SITE AS SHOWN.

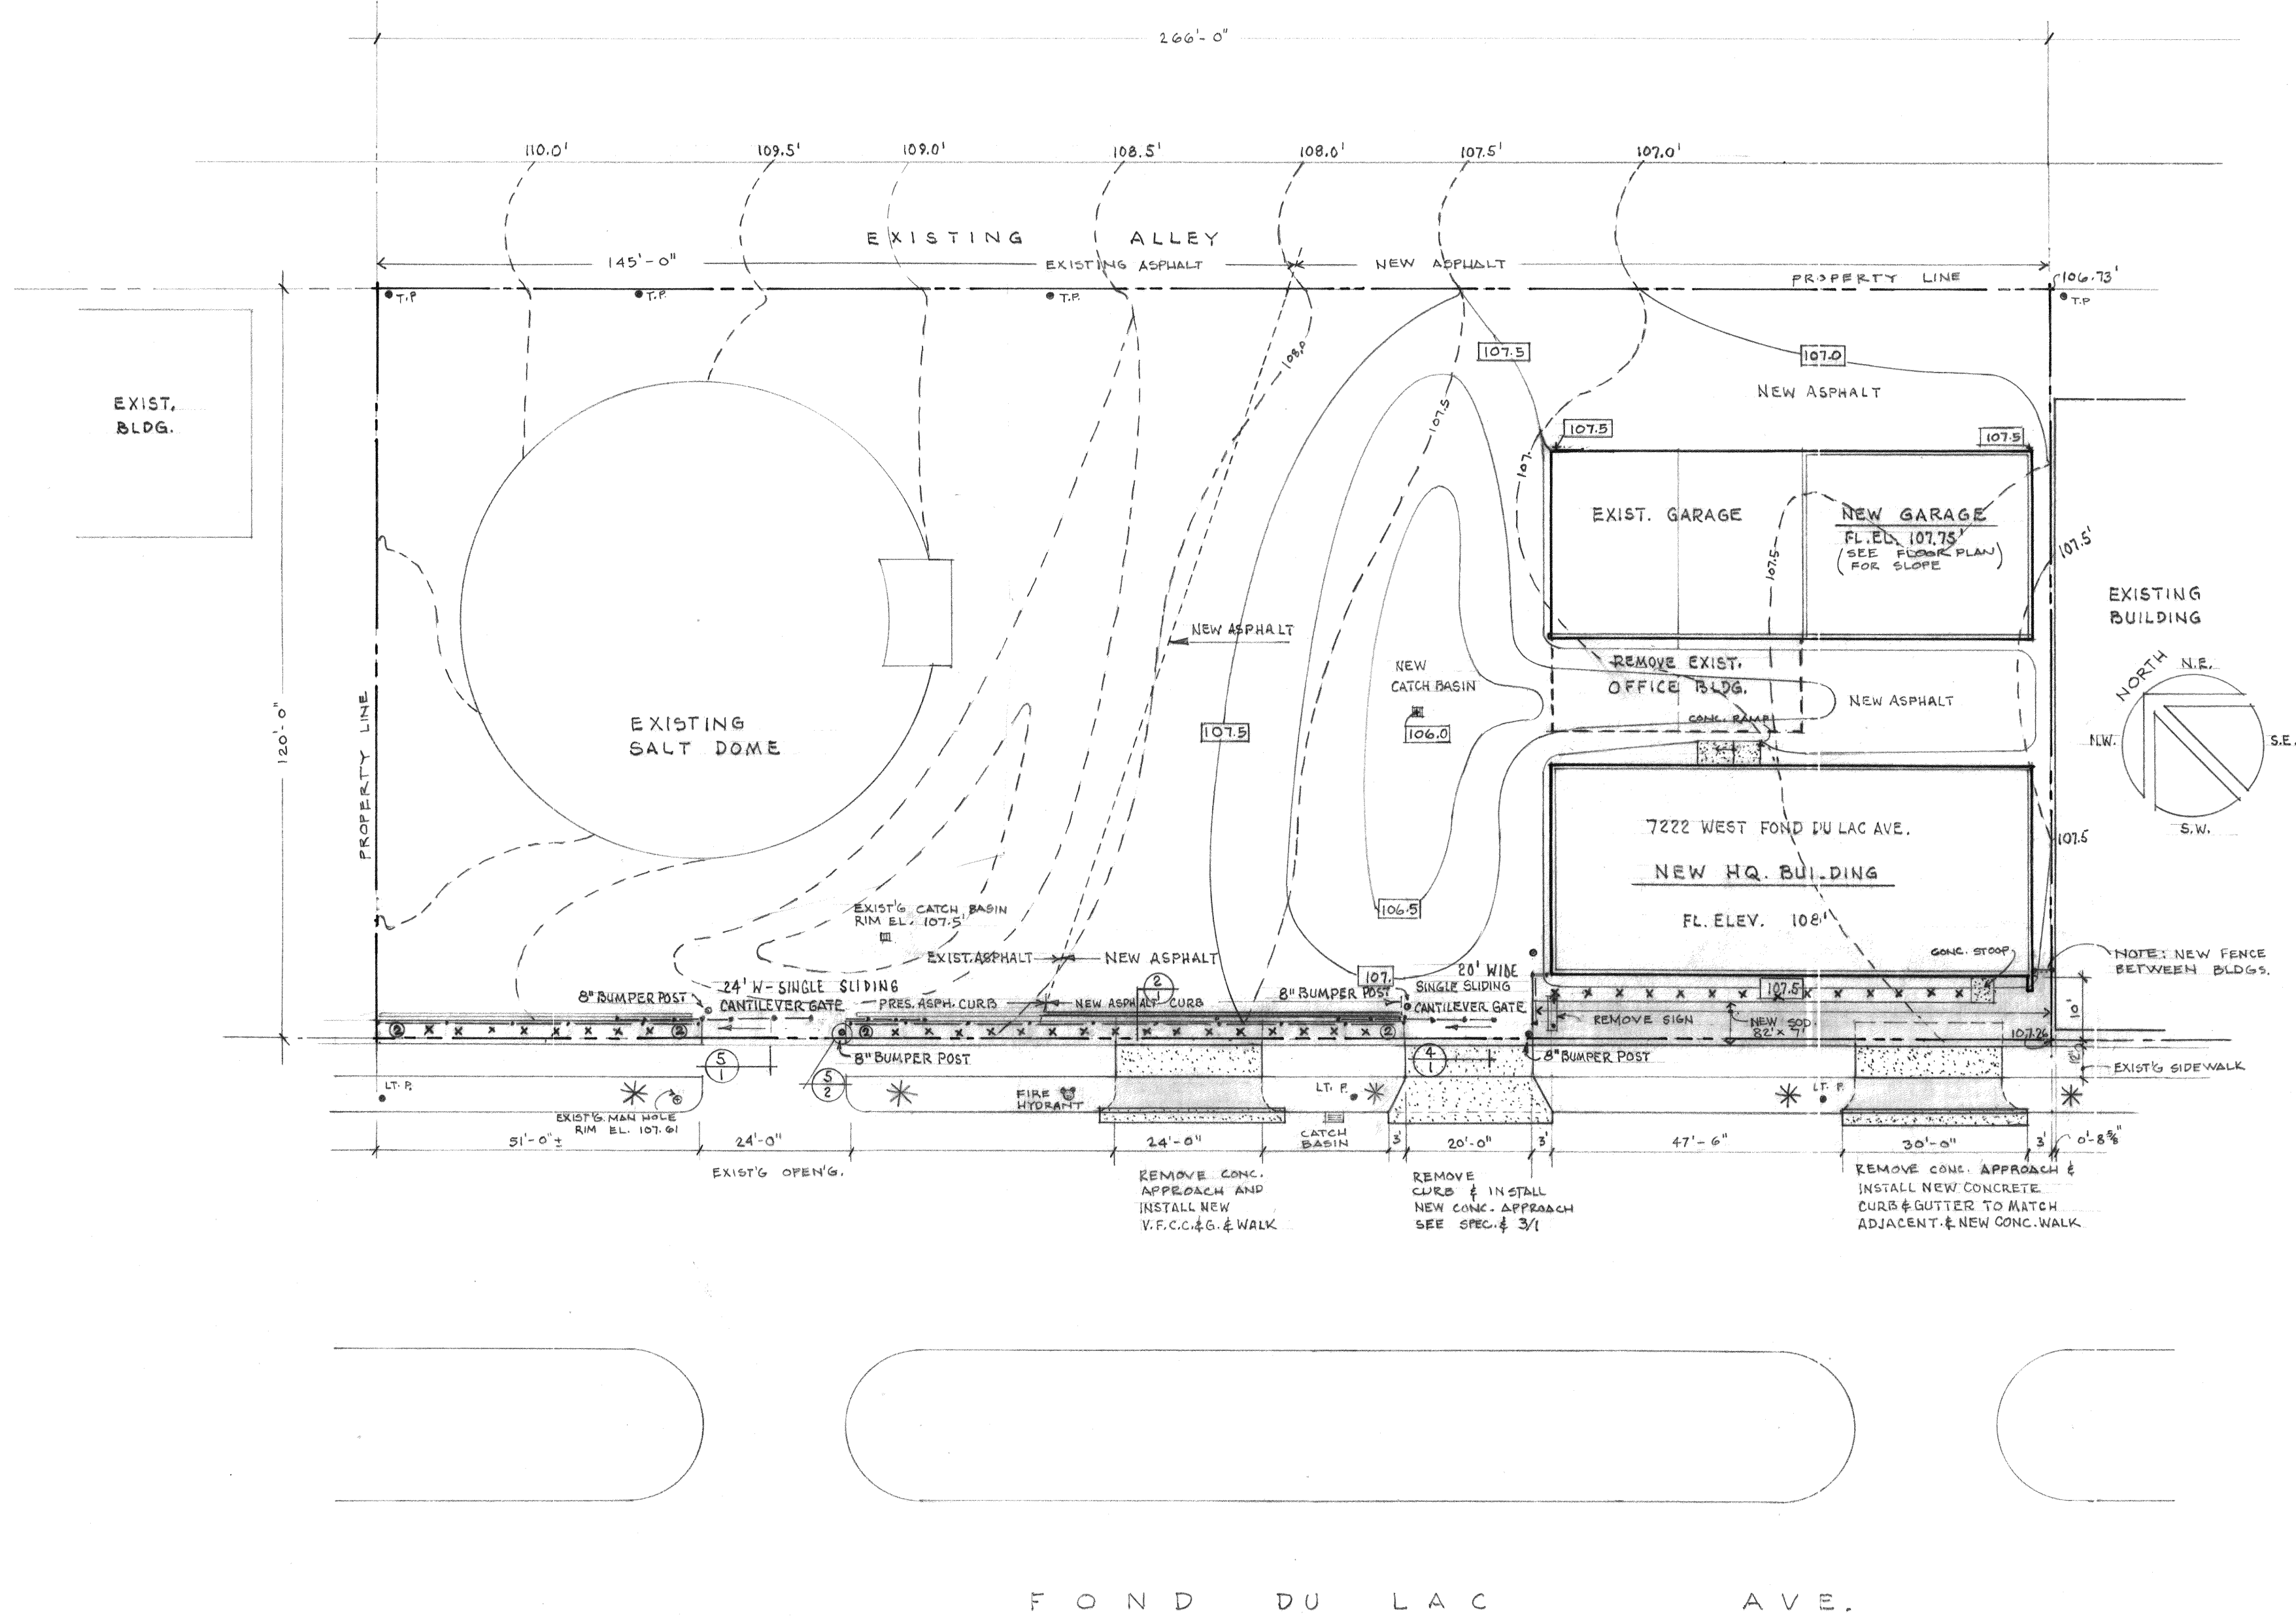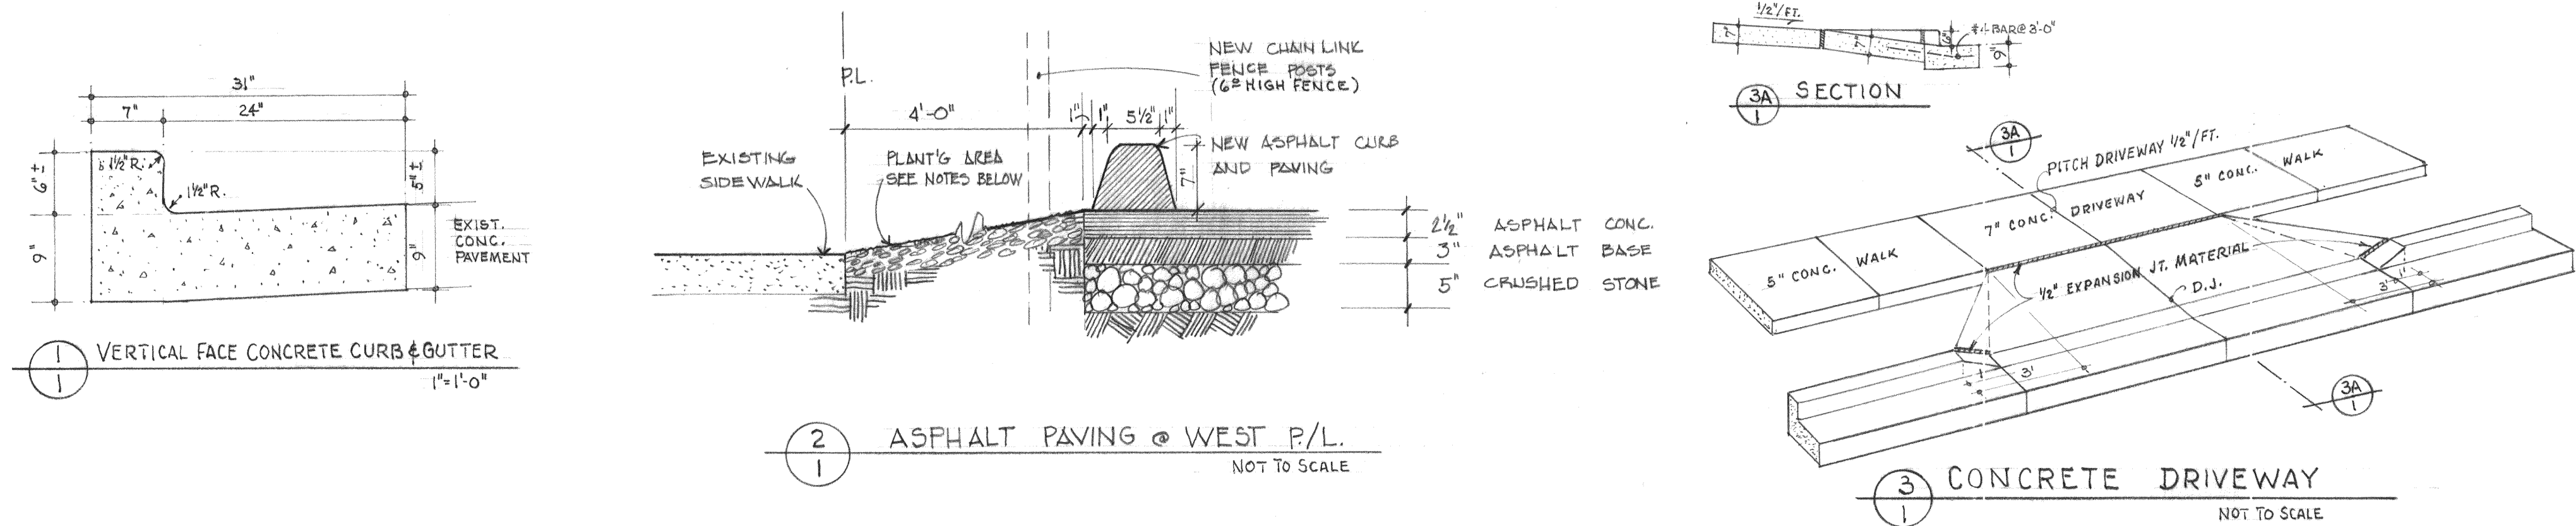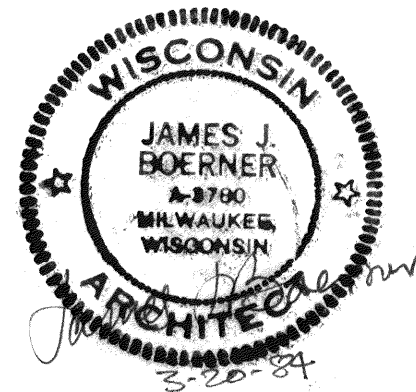



SITE PLAN

1" = 20'









16-D-1
 TYPING POST


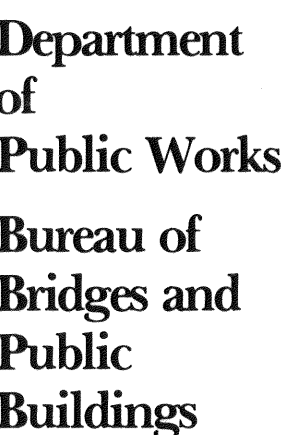


FLOOR PLAN & DETAILS



 
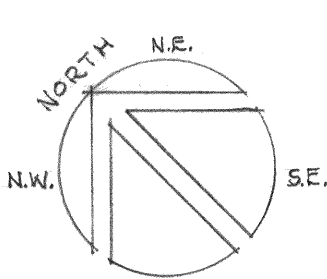


16-D-1


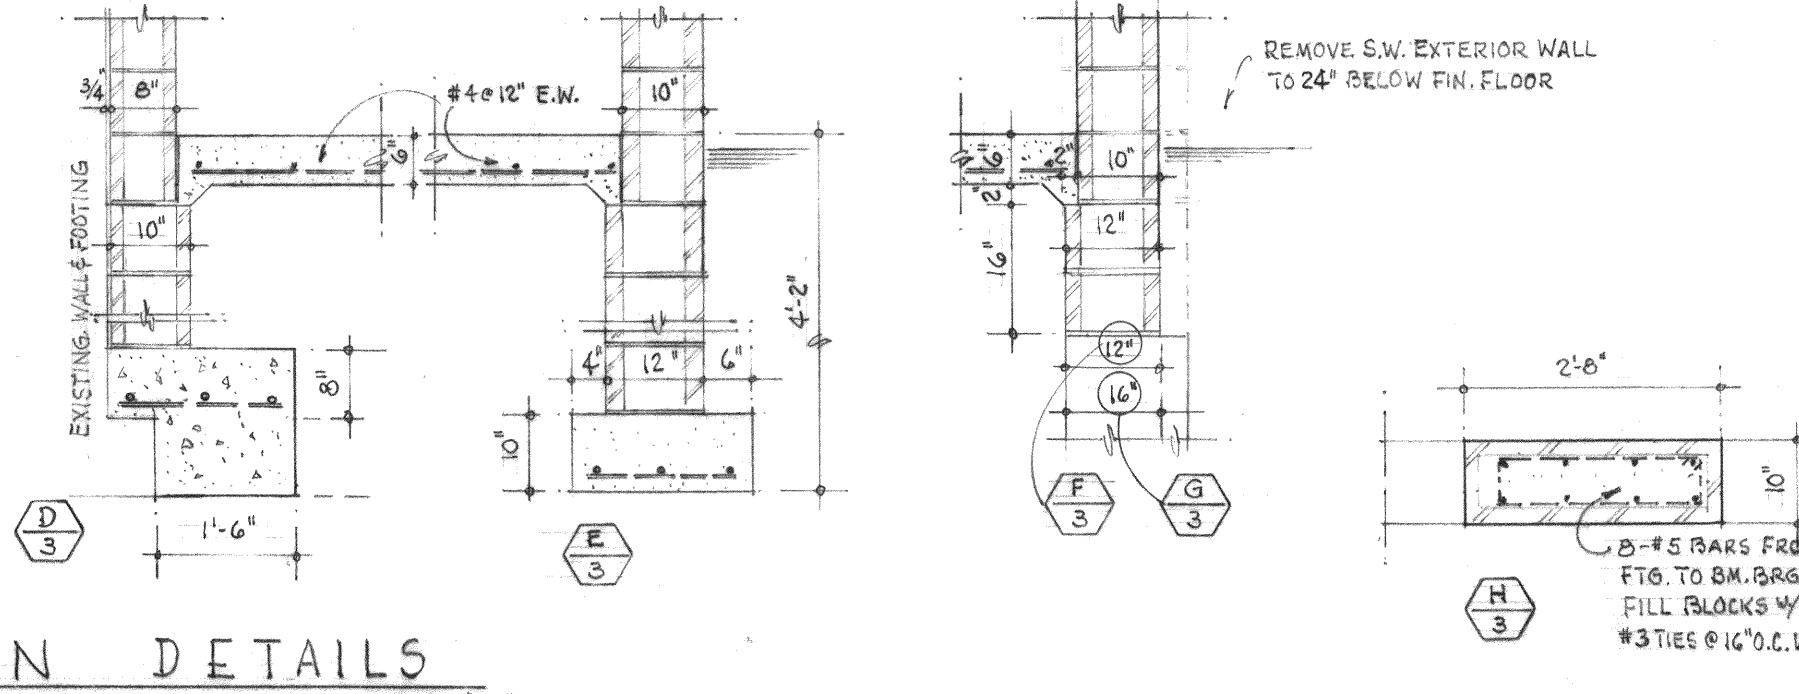
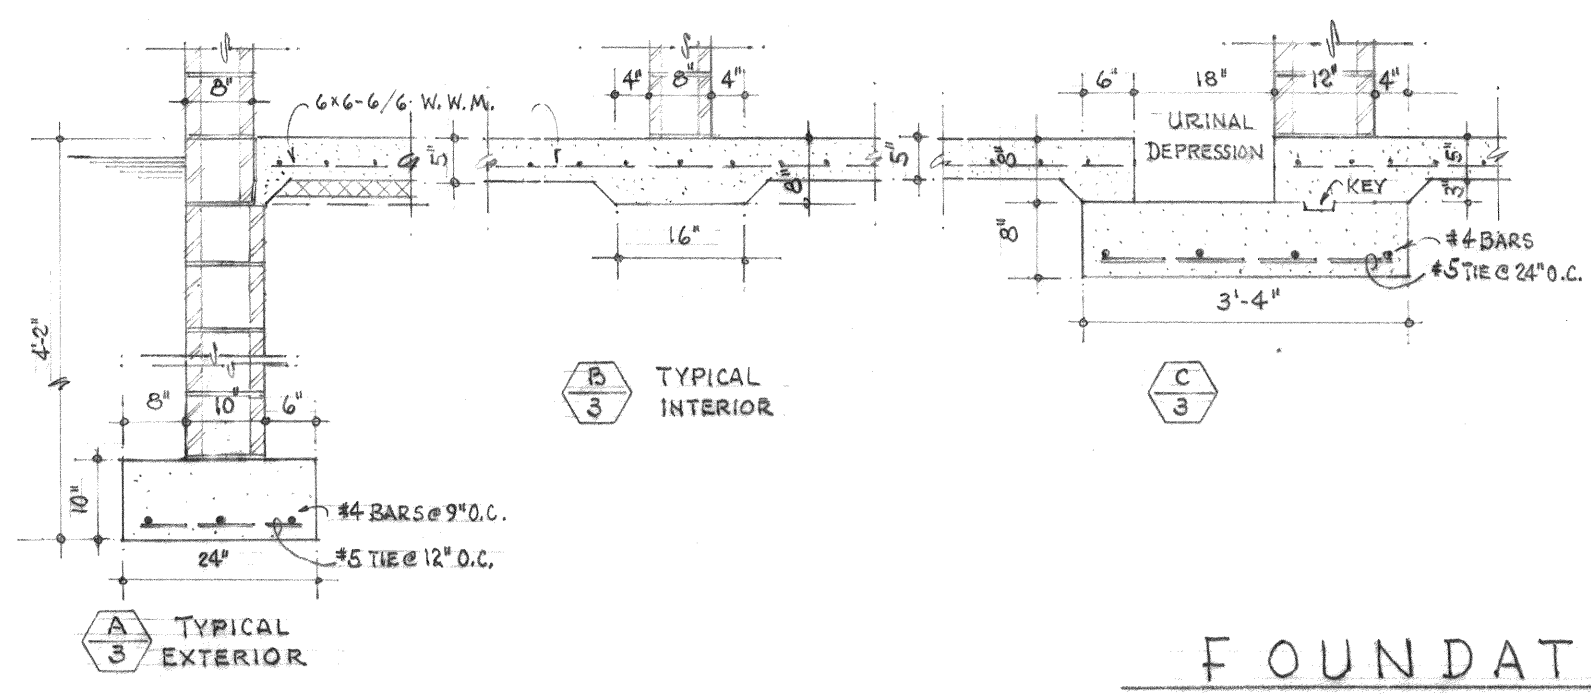
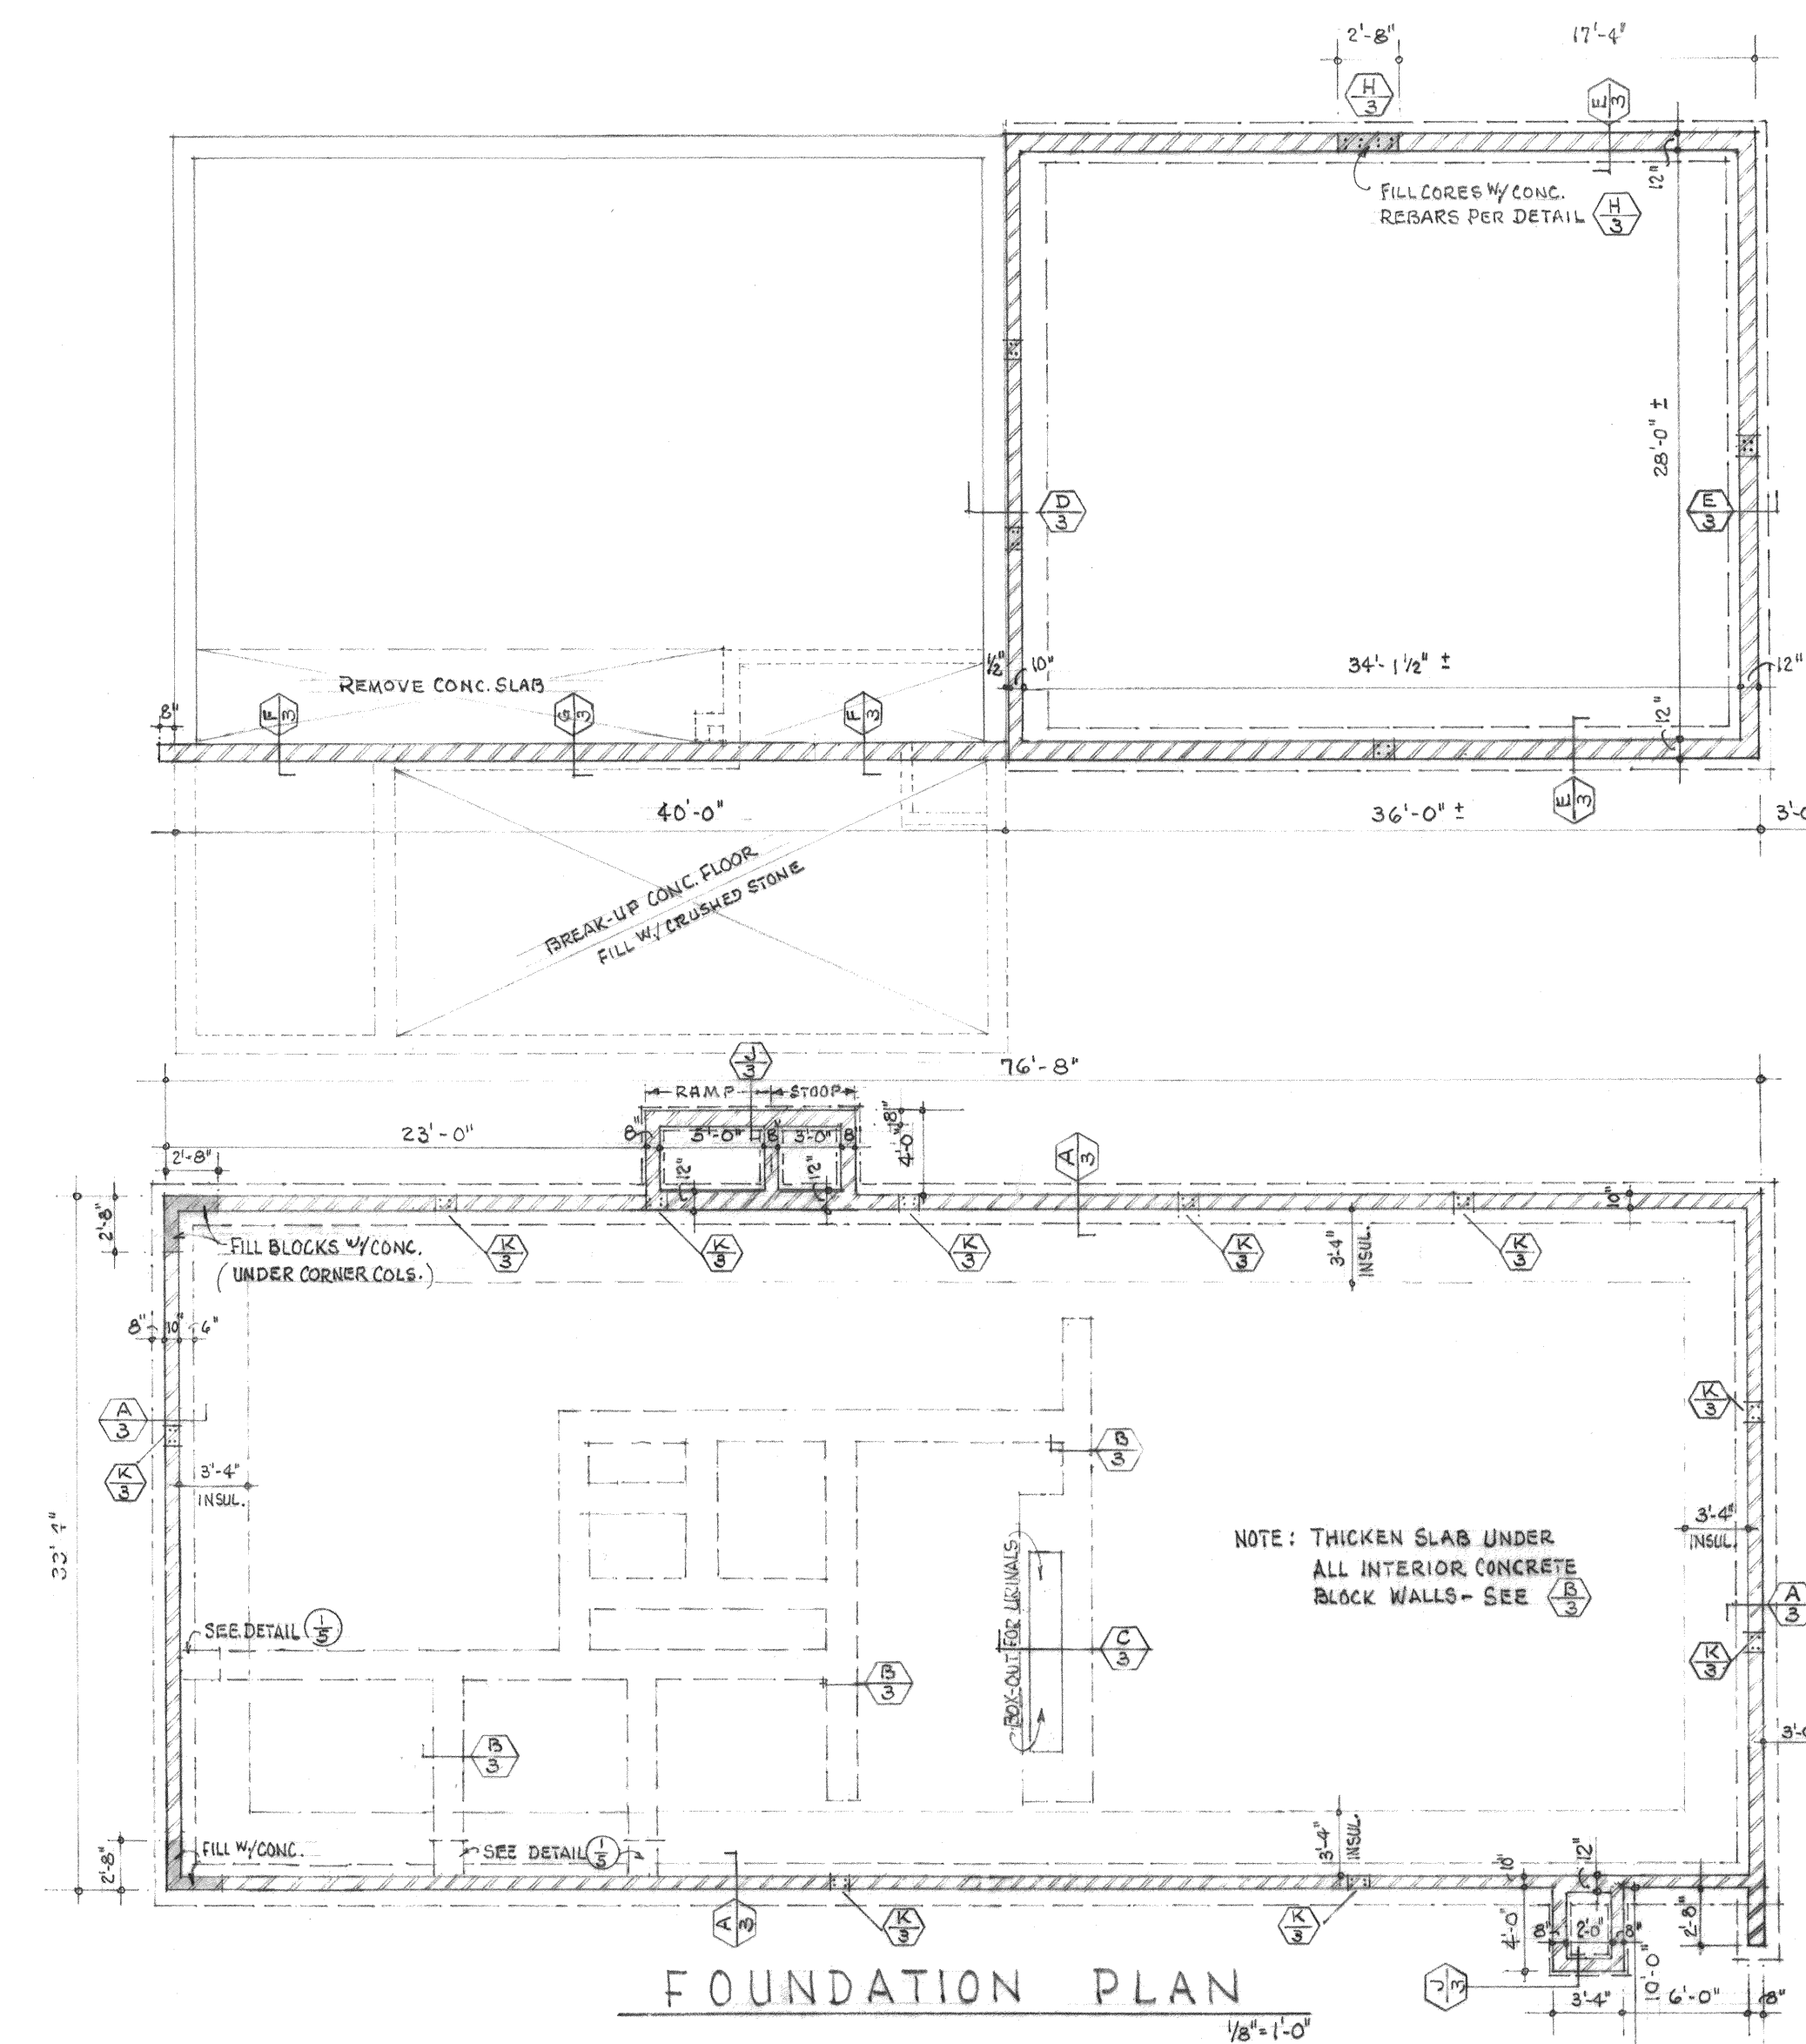
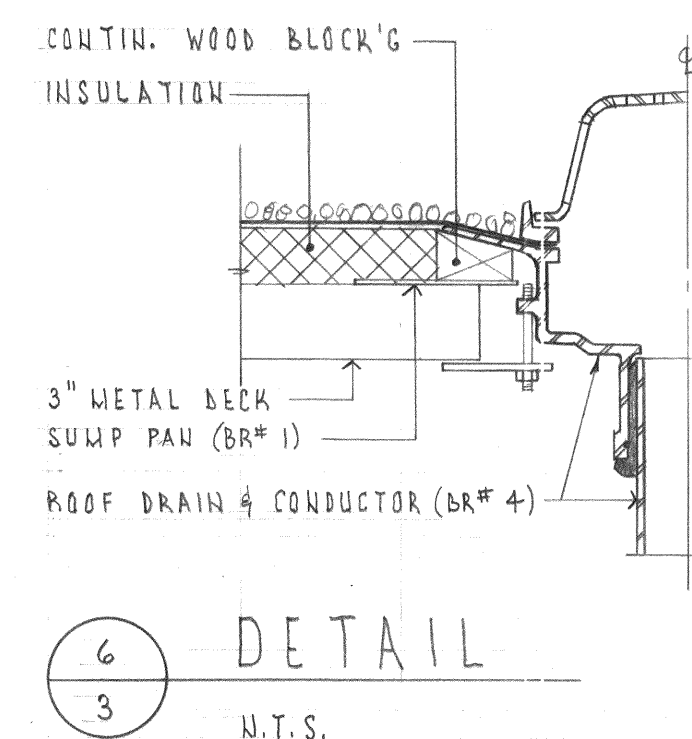
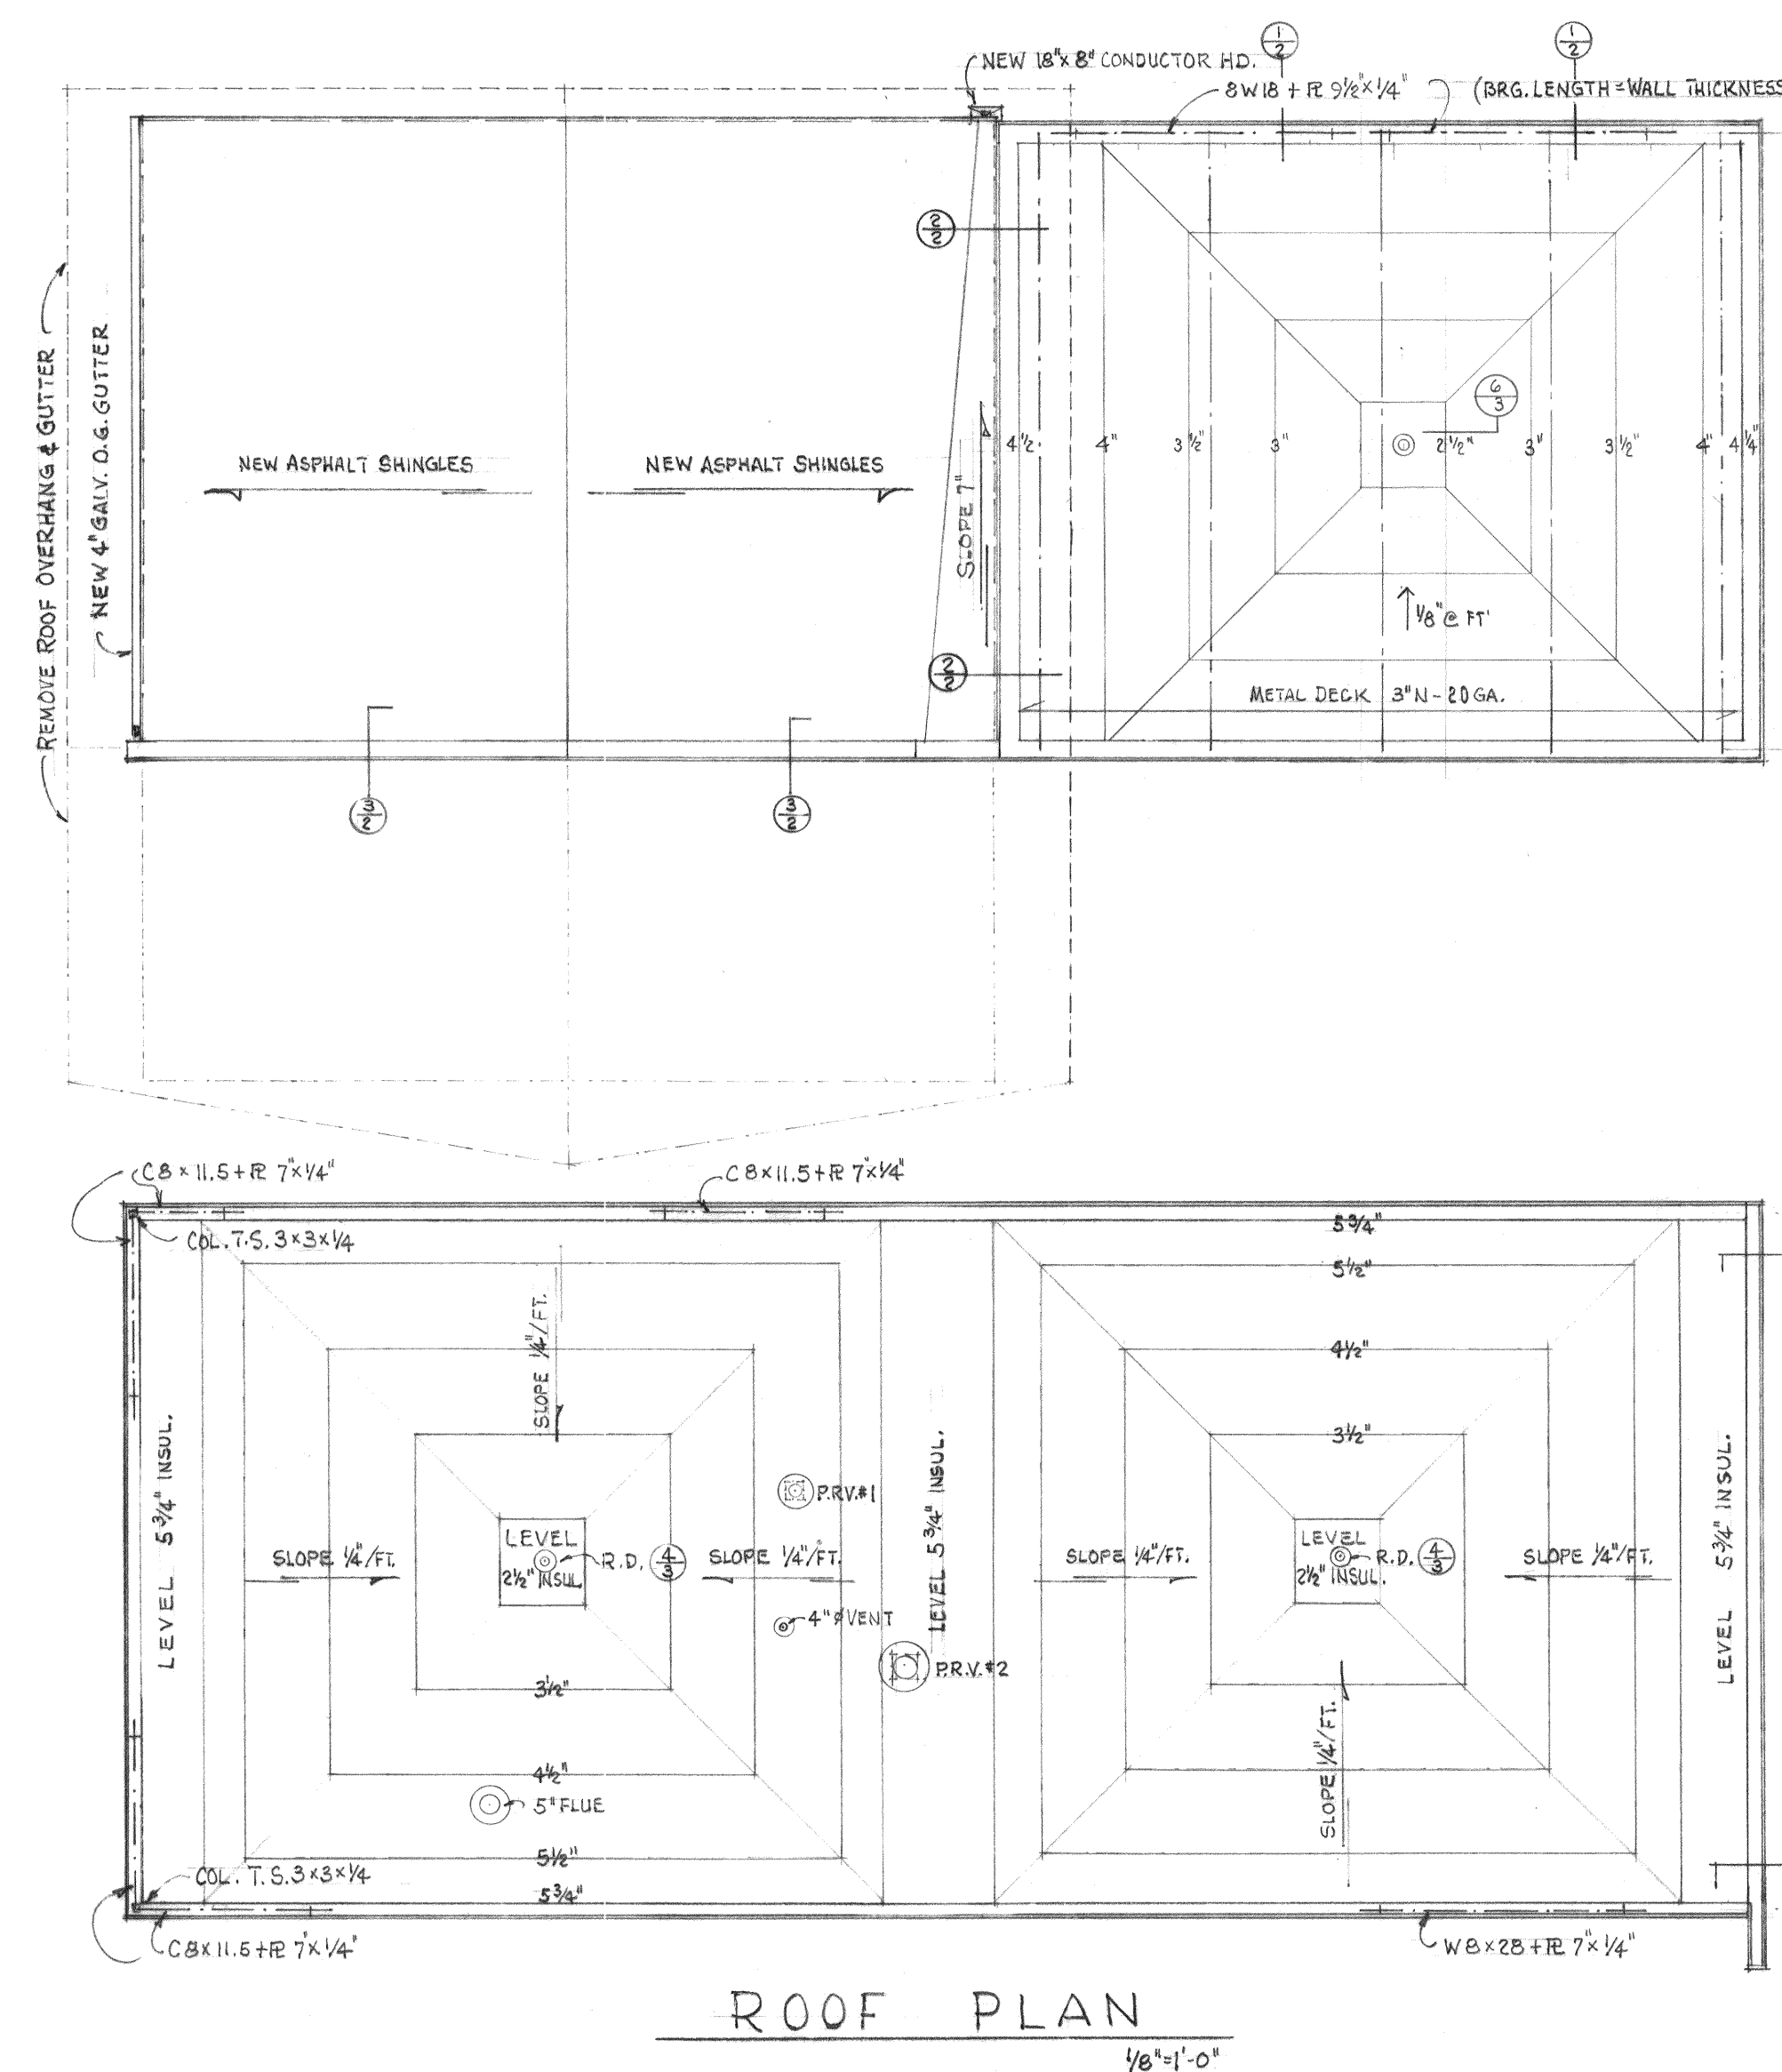
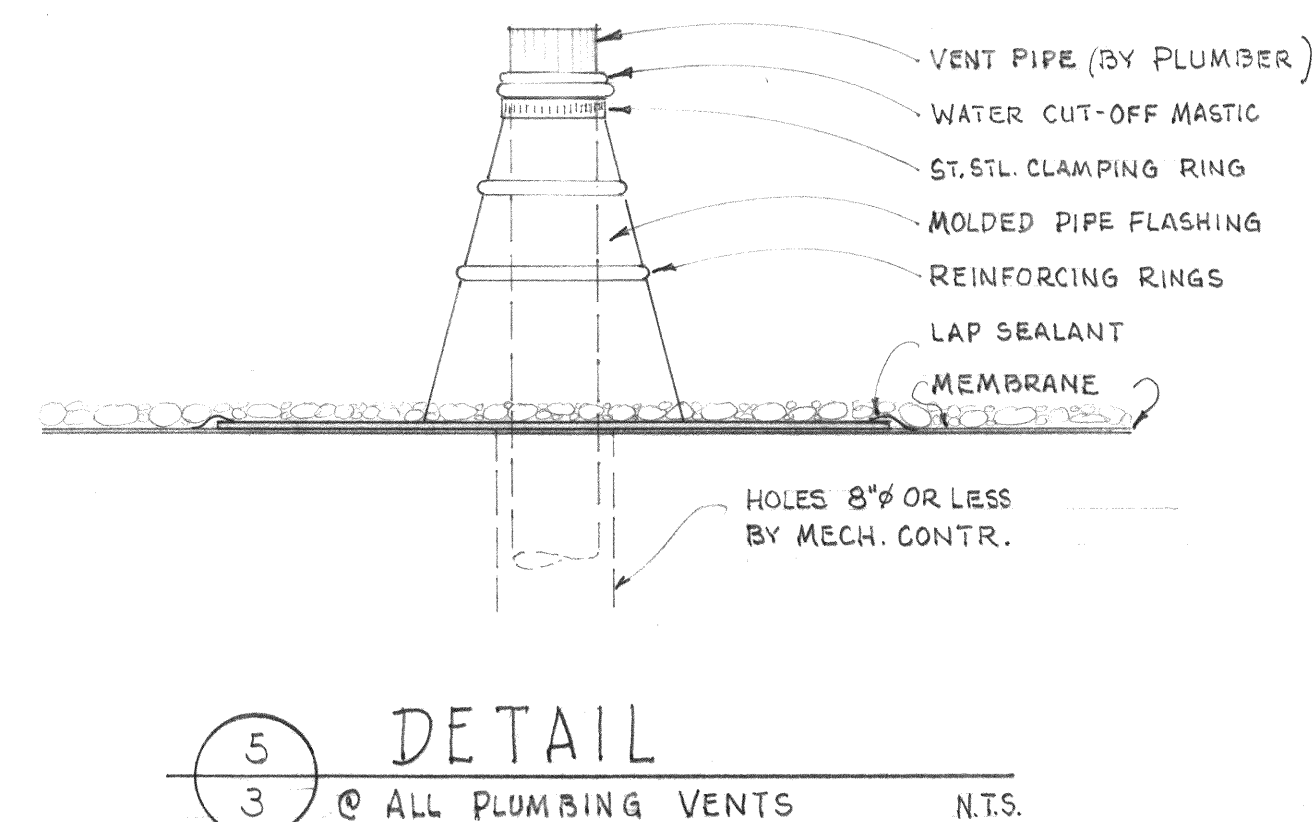
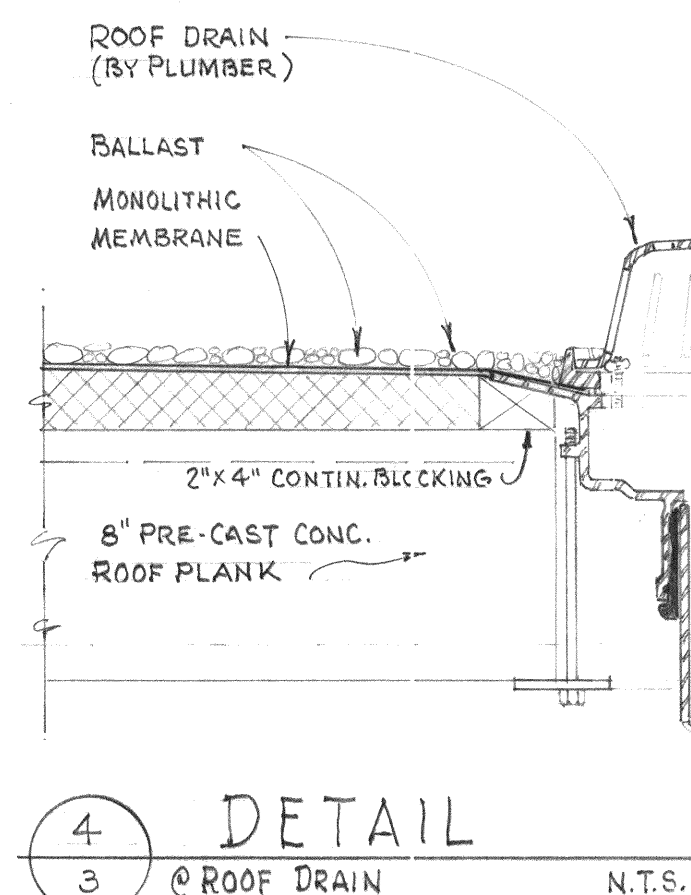
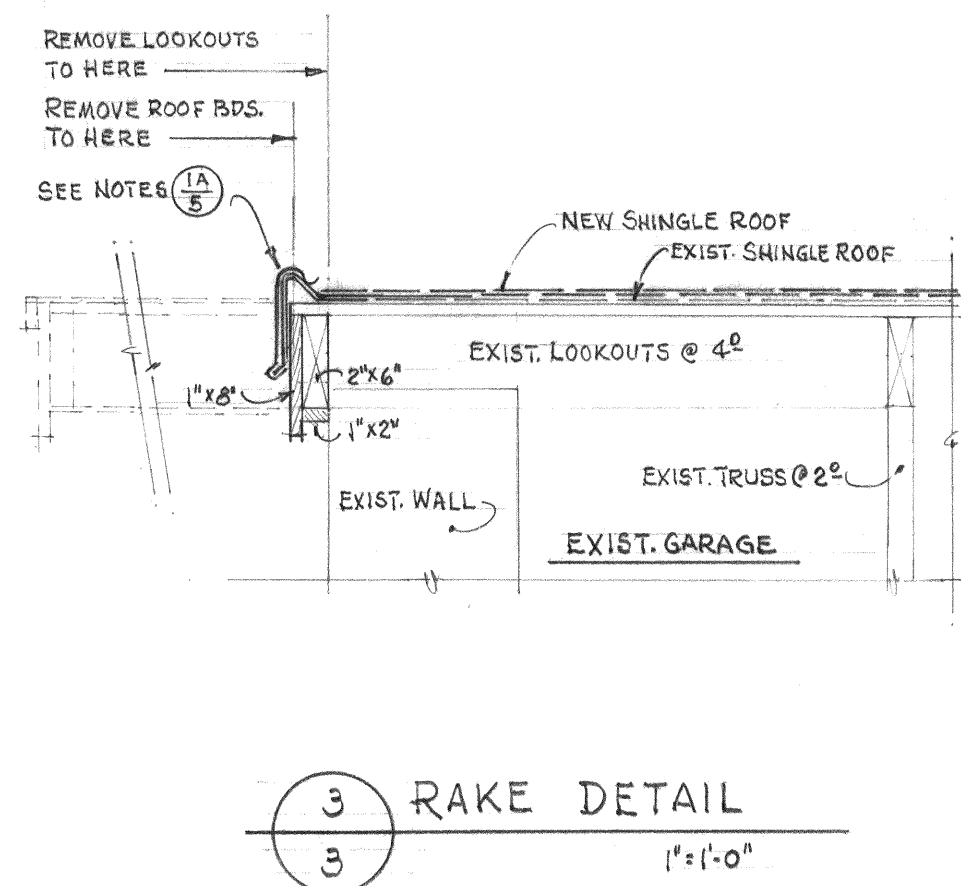


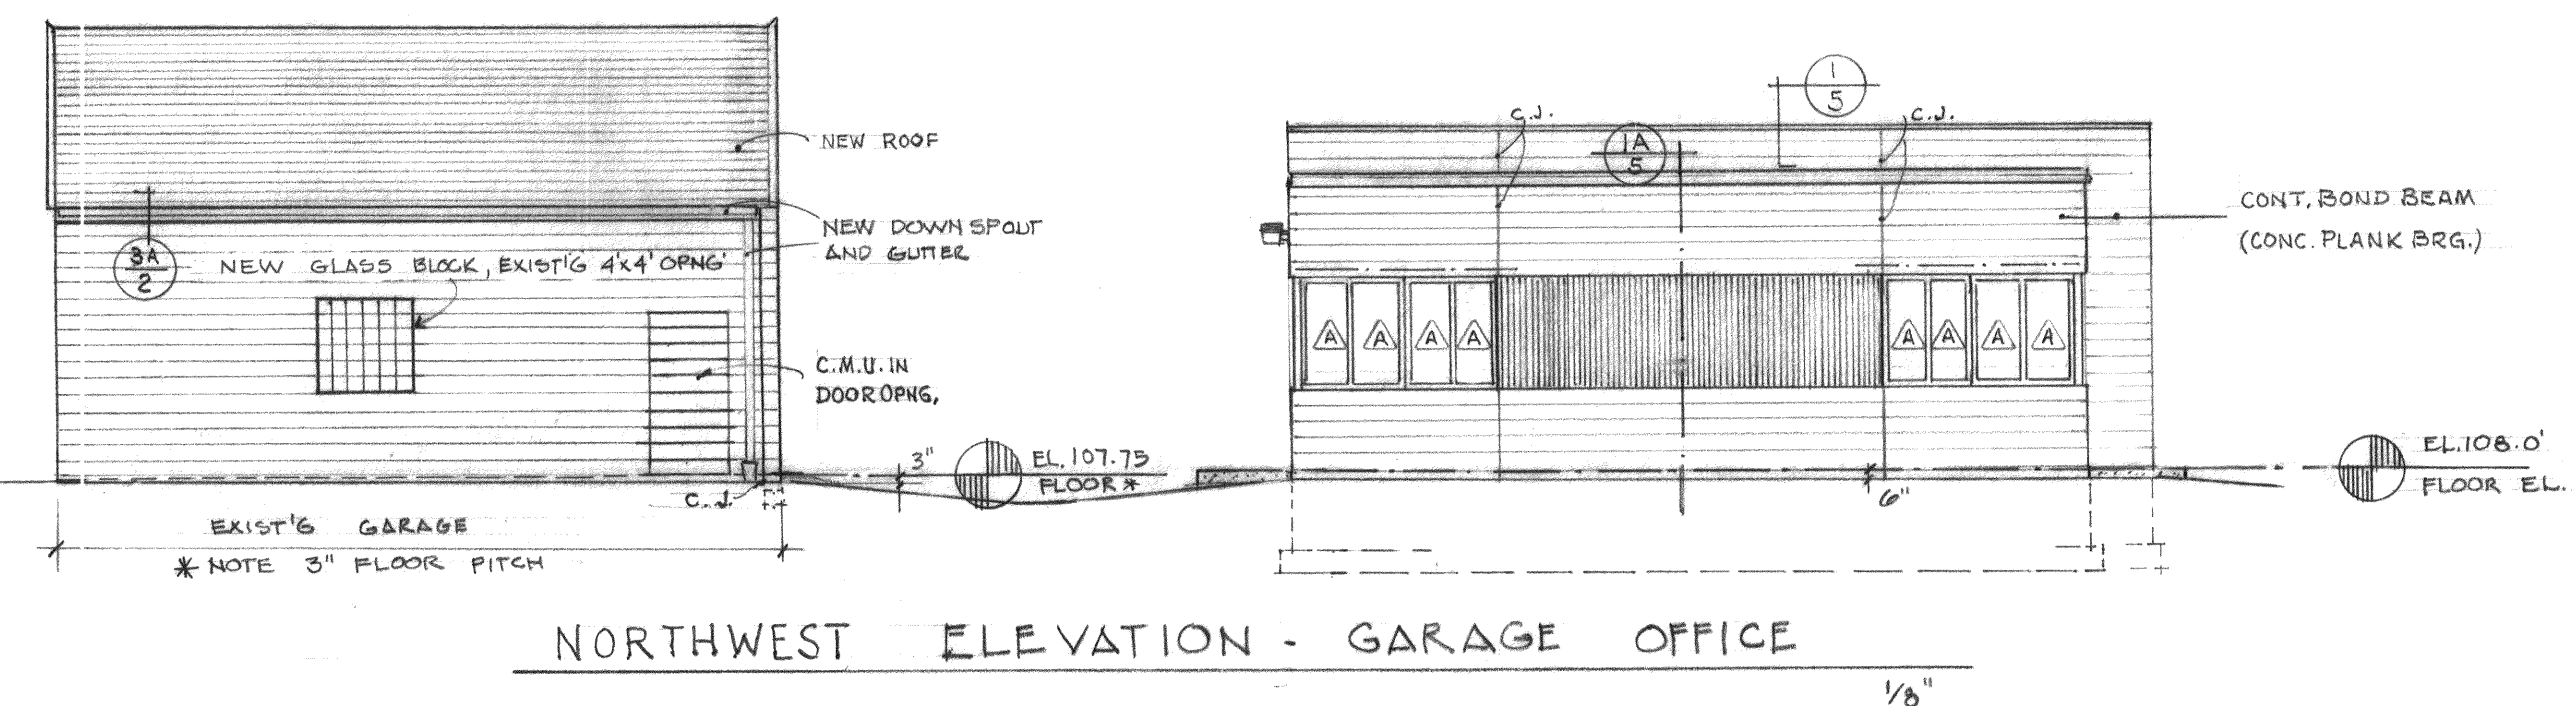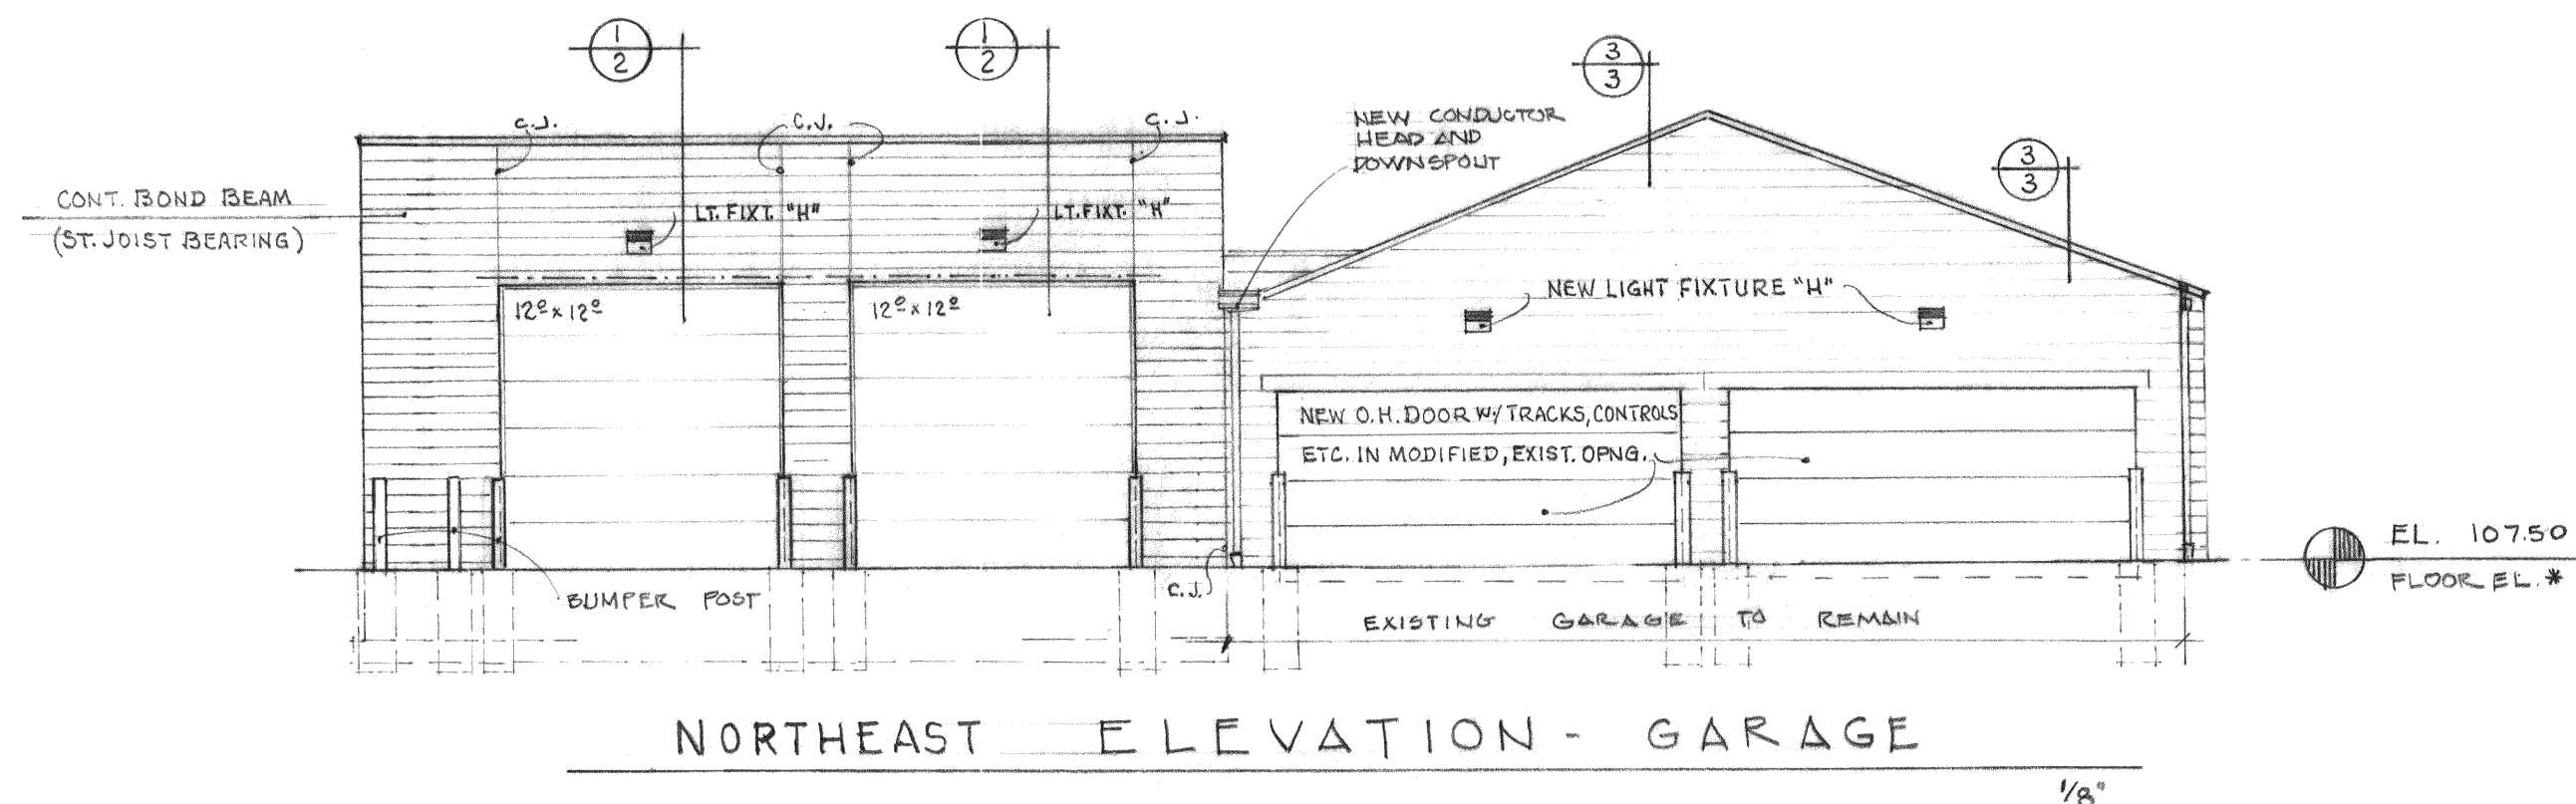


NOTE
3" FLOOR PITCH FROM WEST TO EAST ELEVATIONS OF GARAGE *
C.J. - CONTROL JOINTS

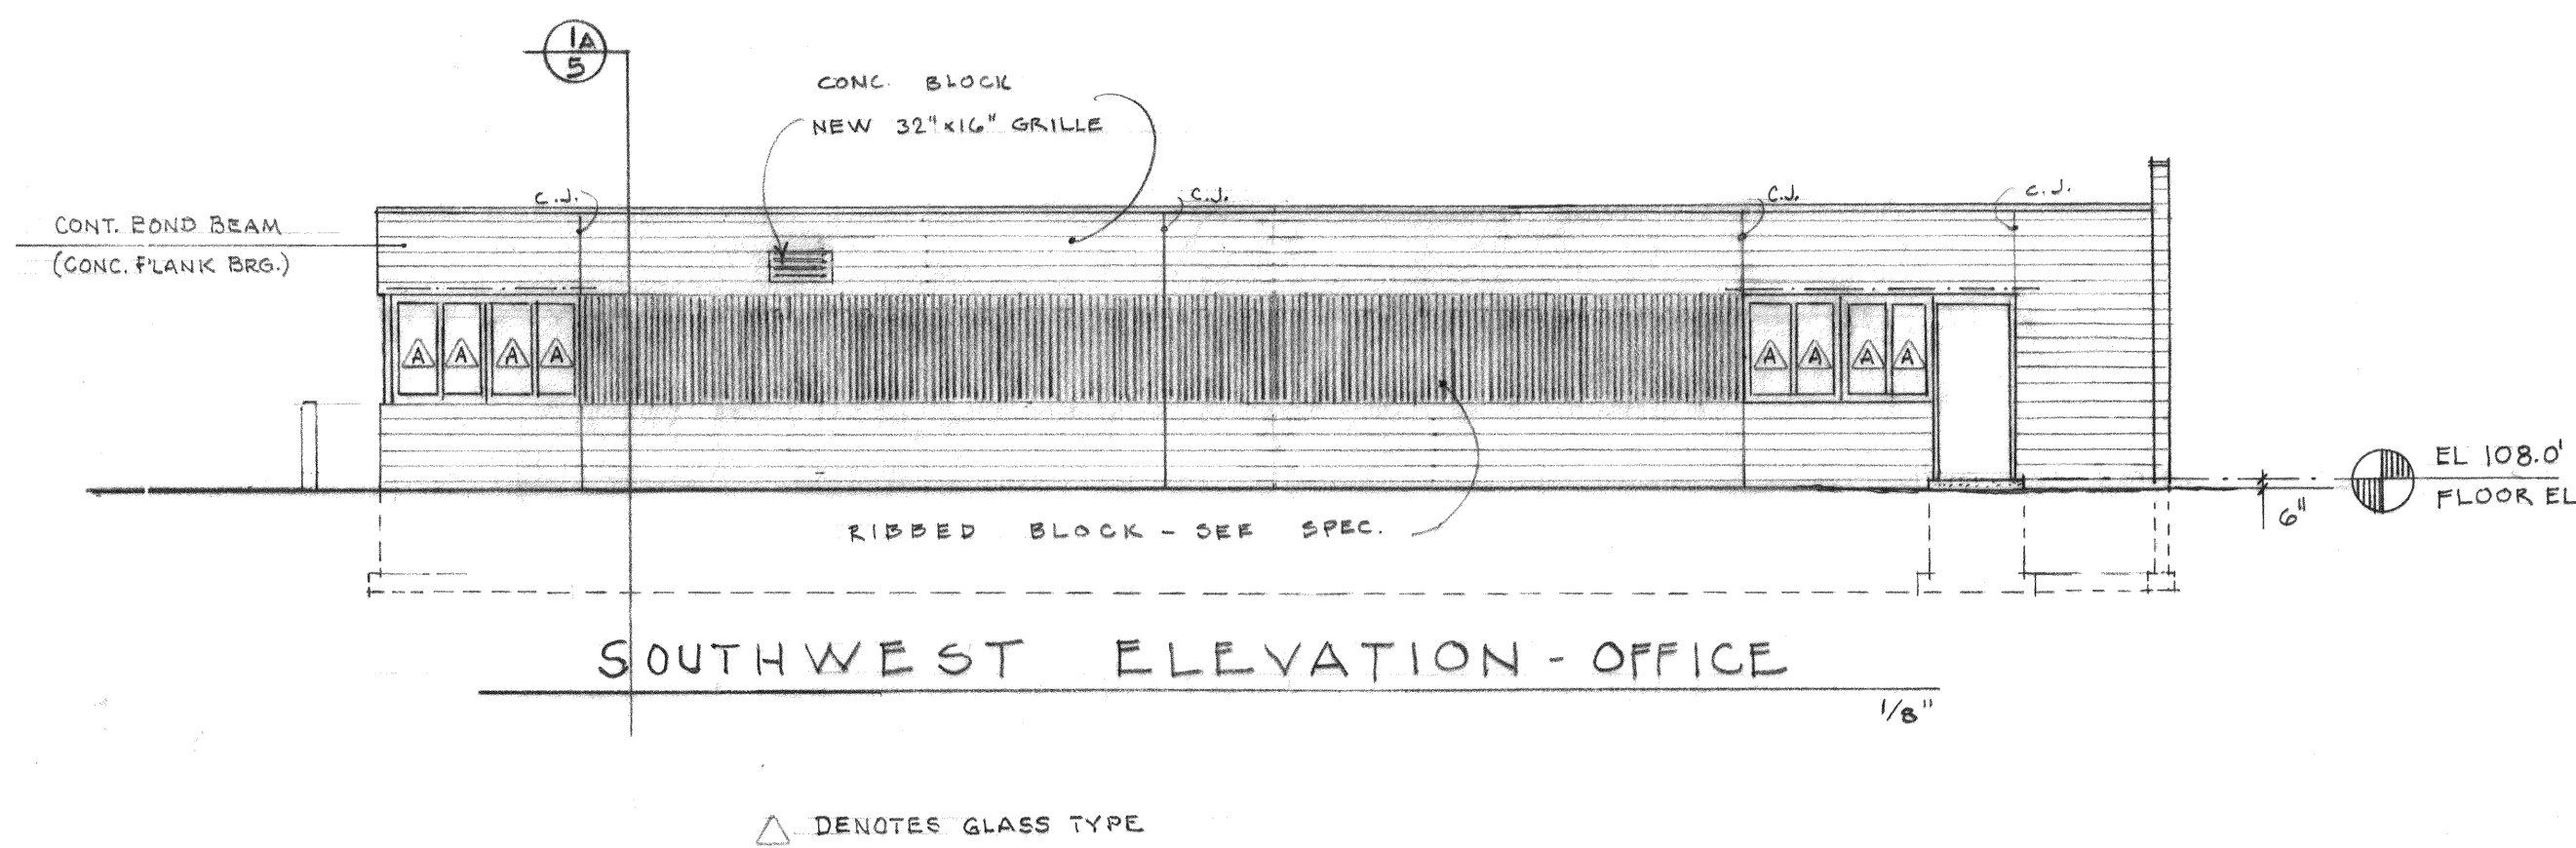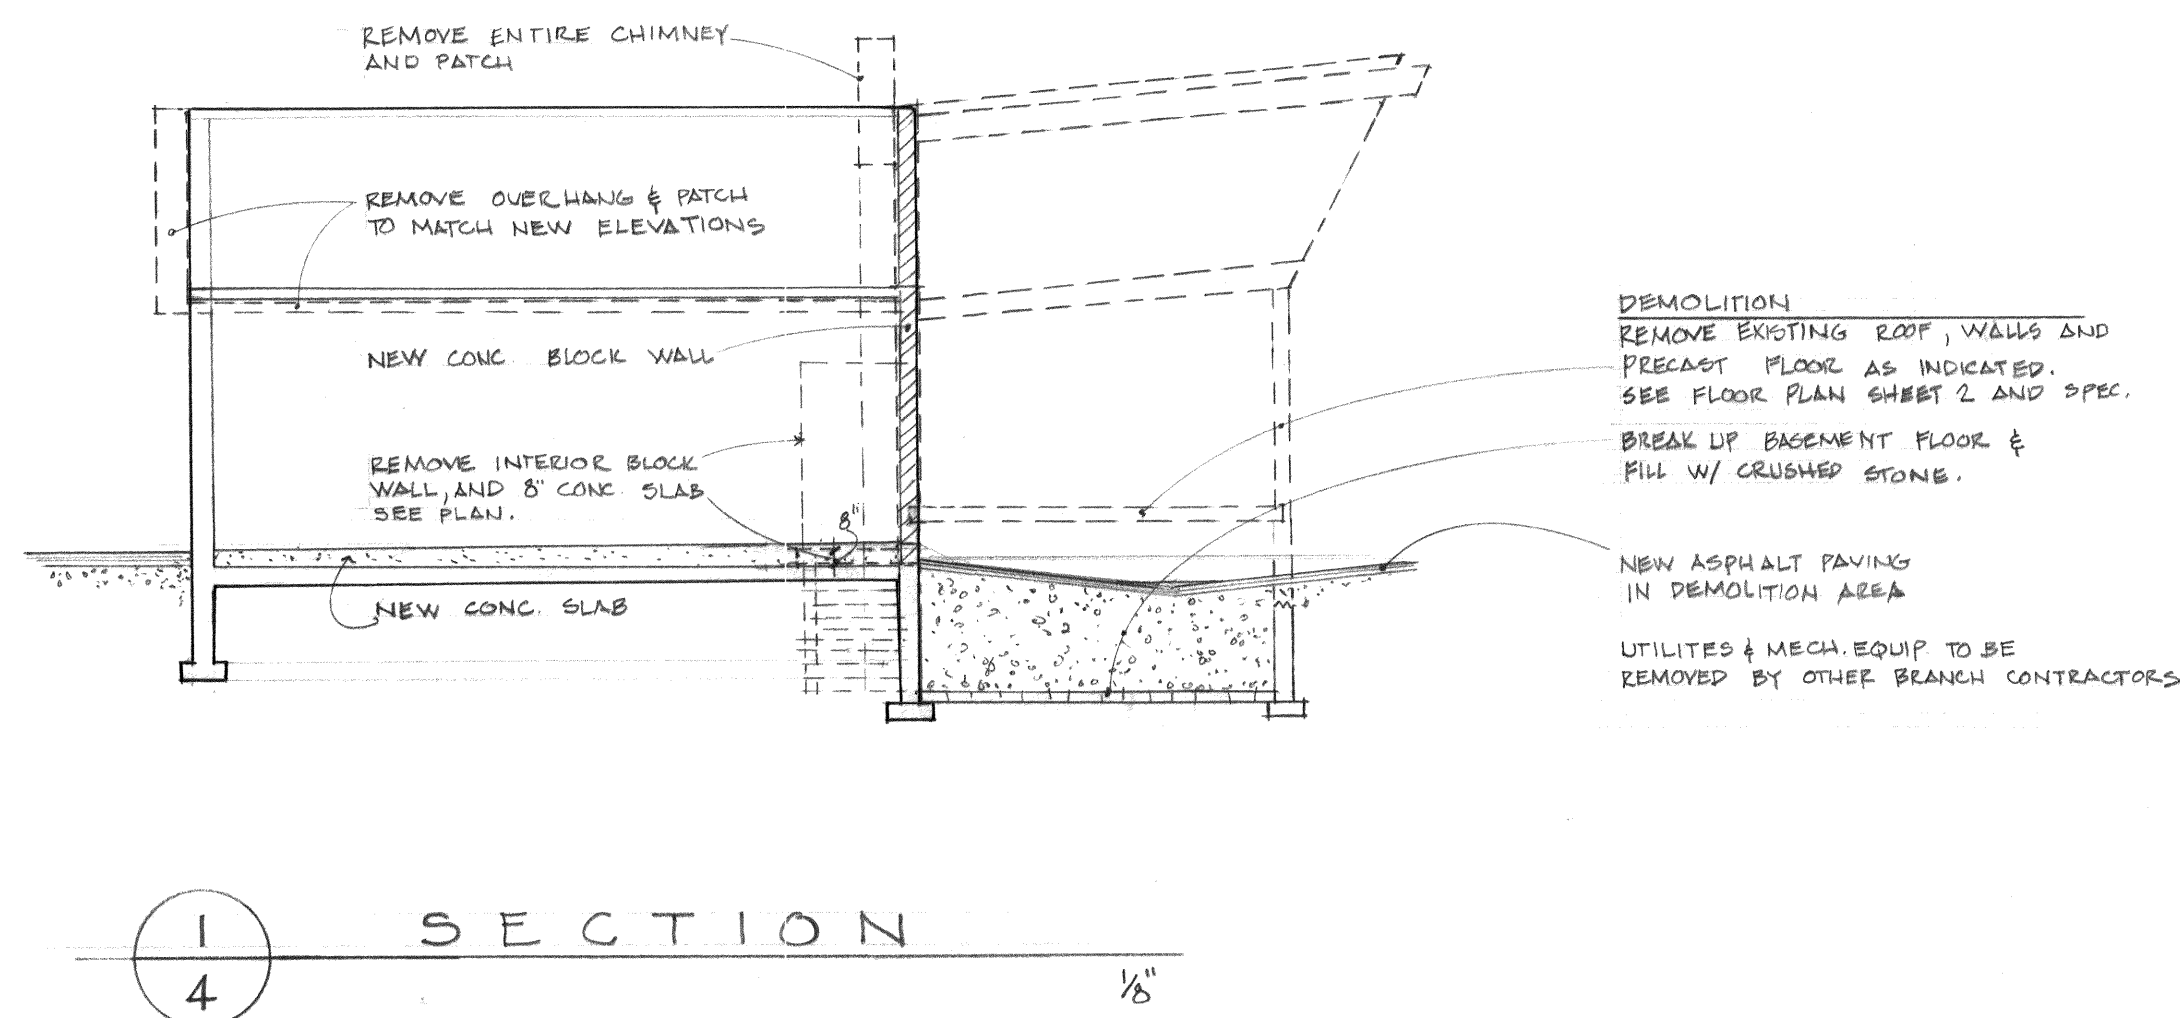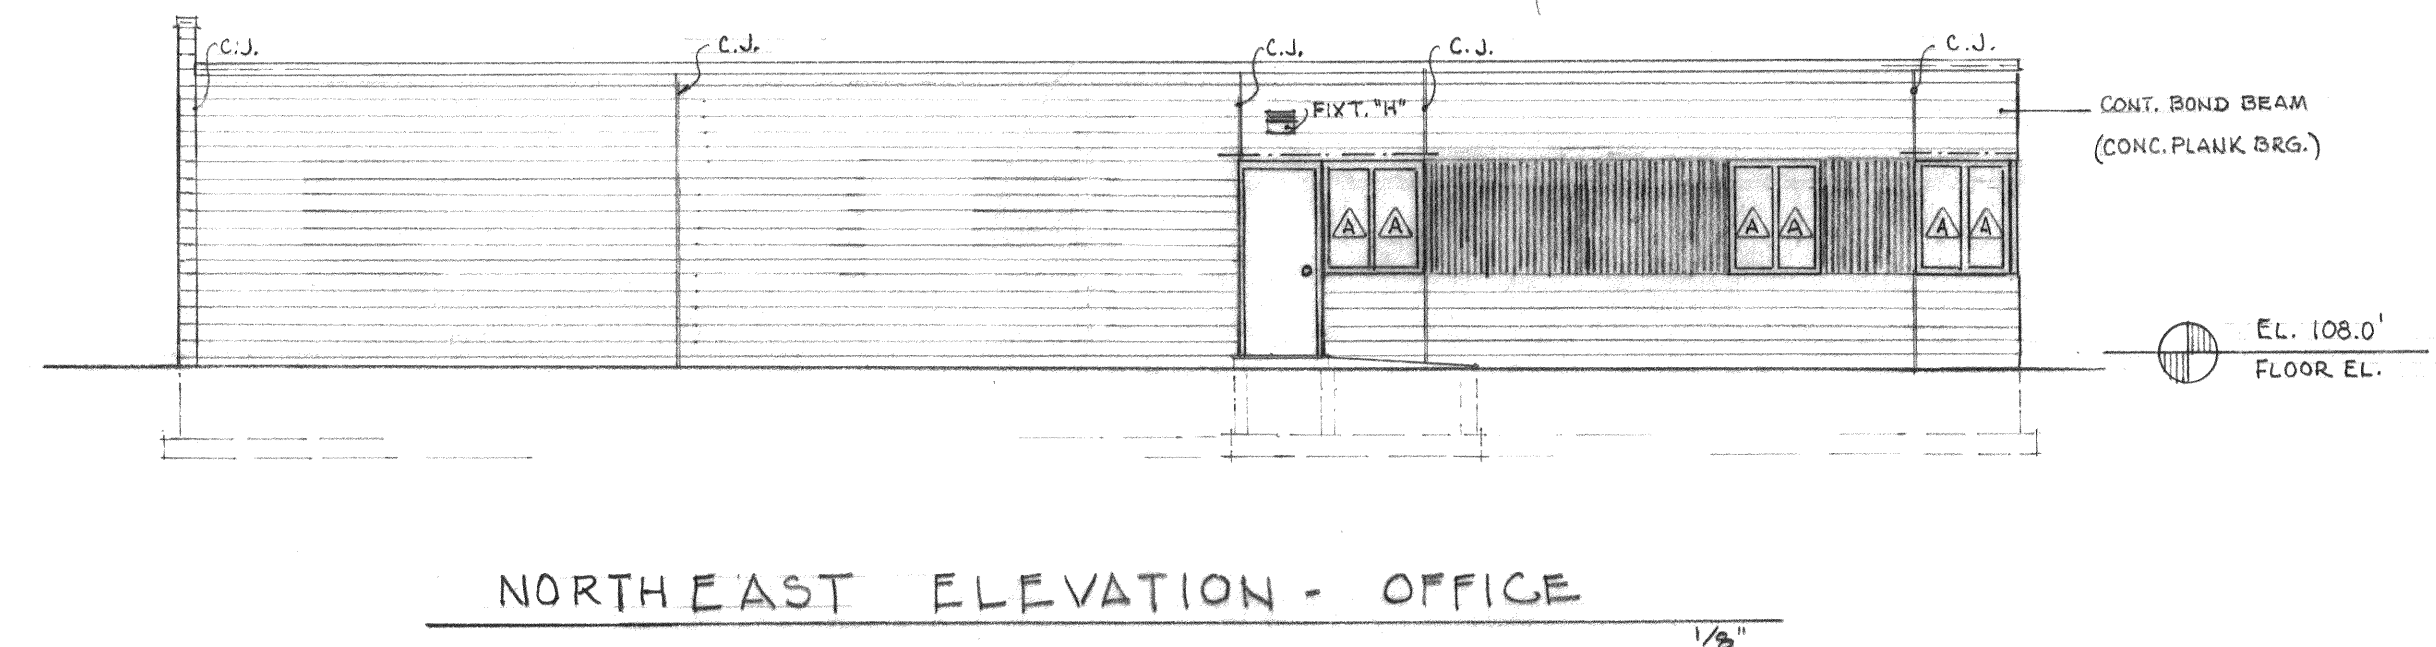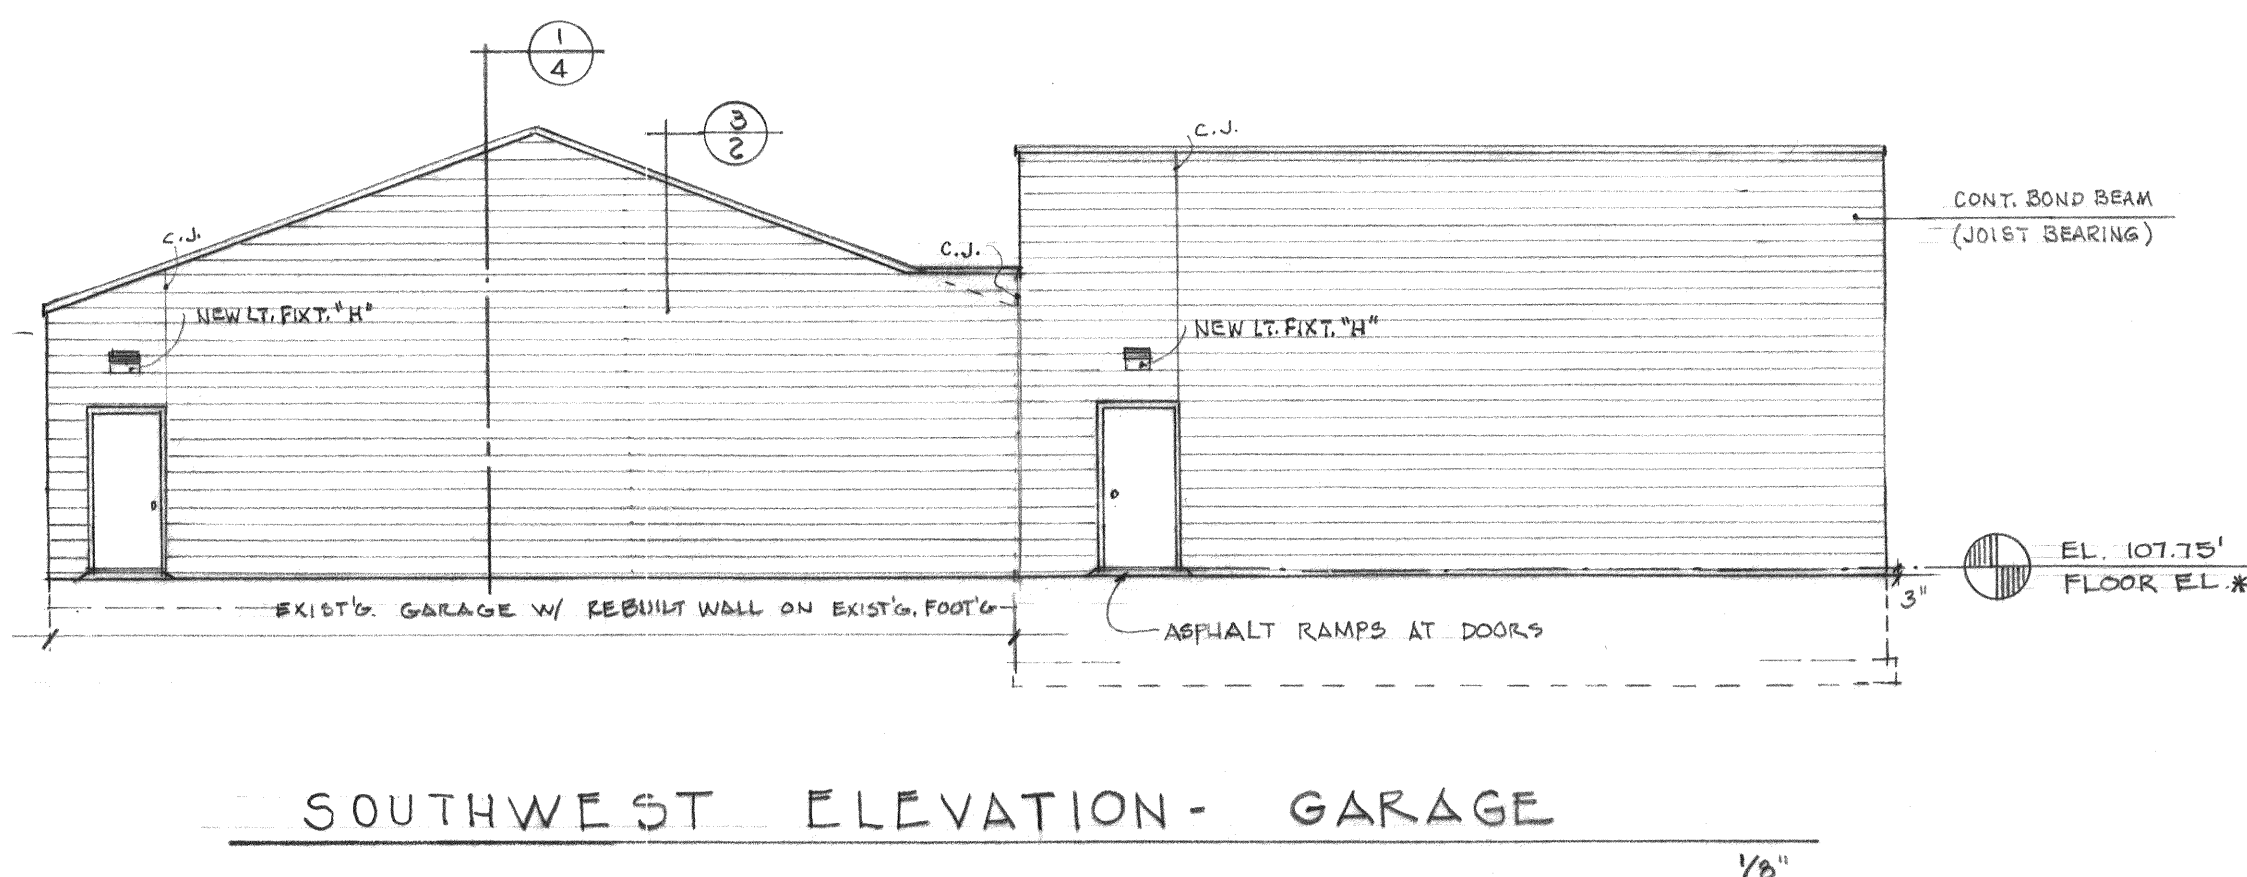


△ DENOTES GLASS TYPE

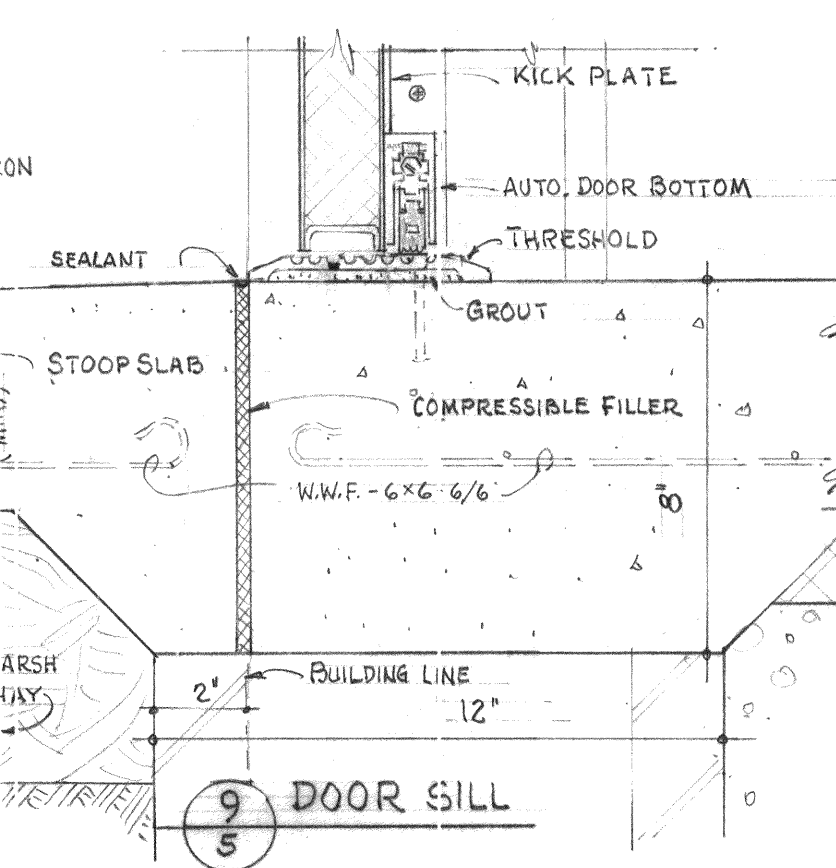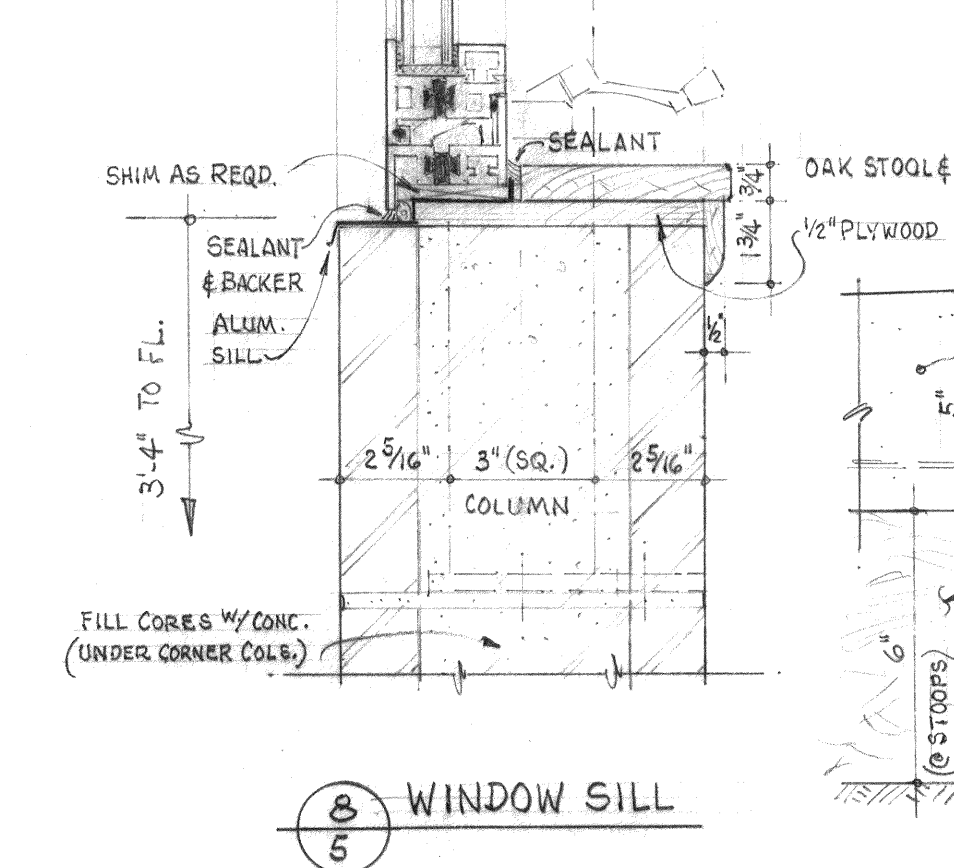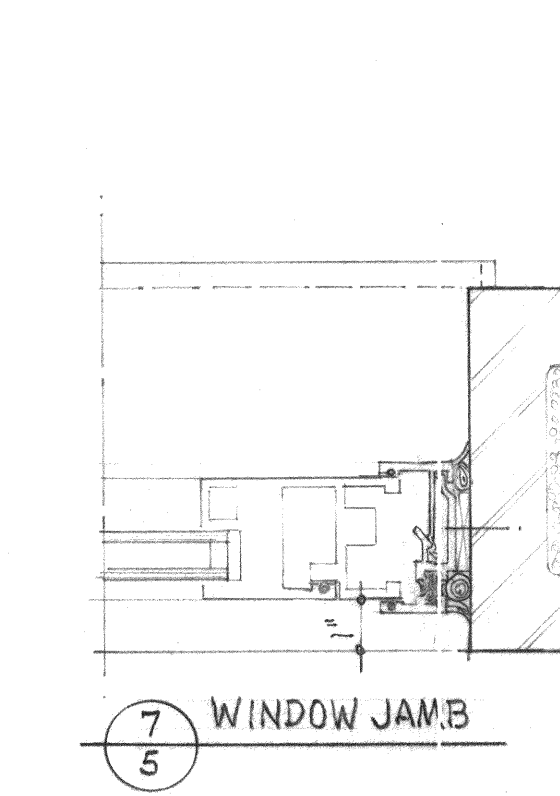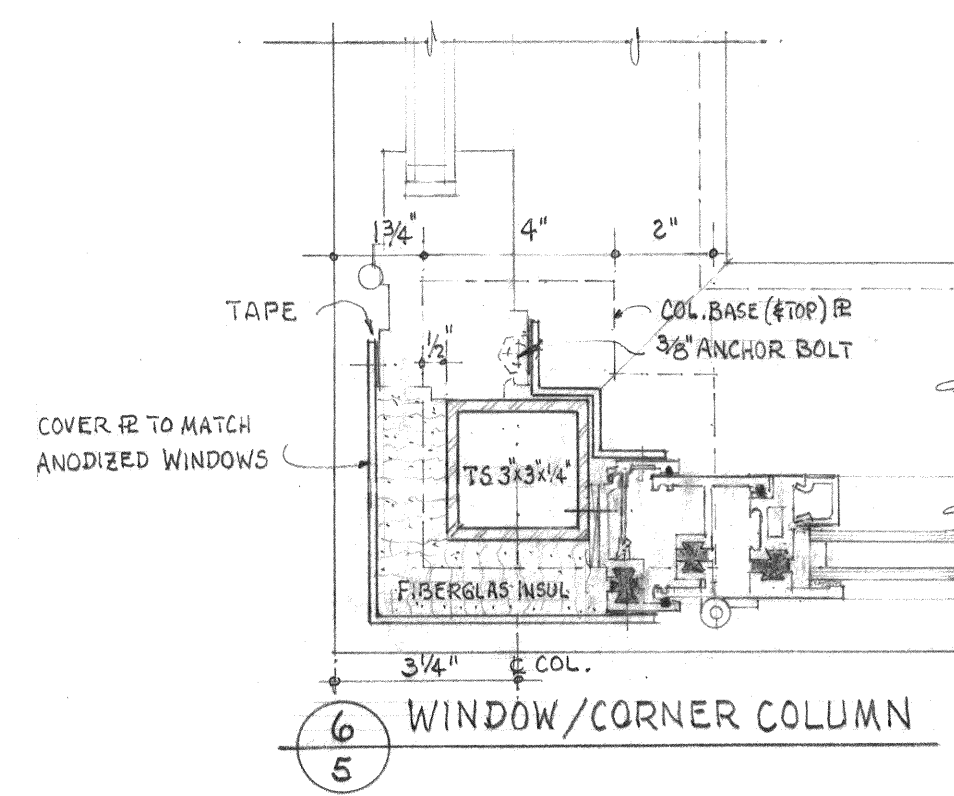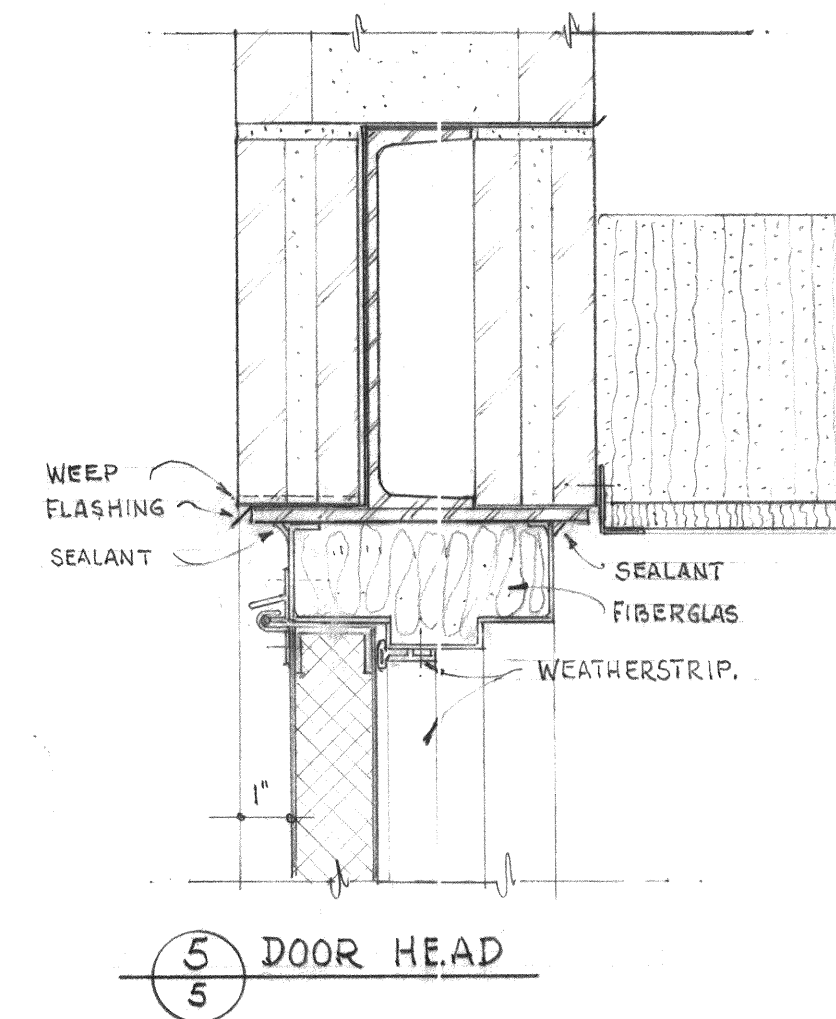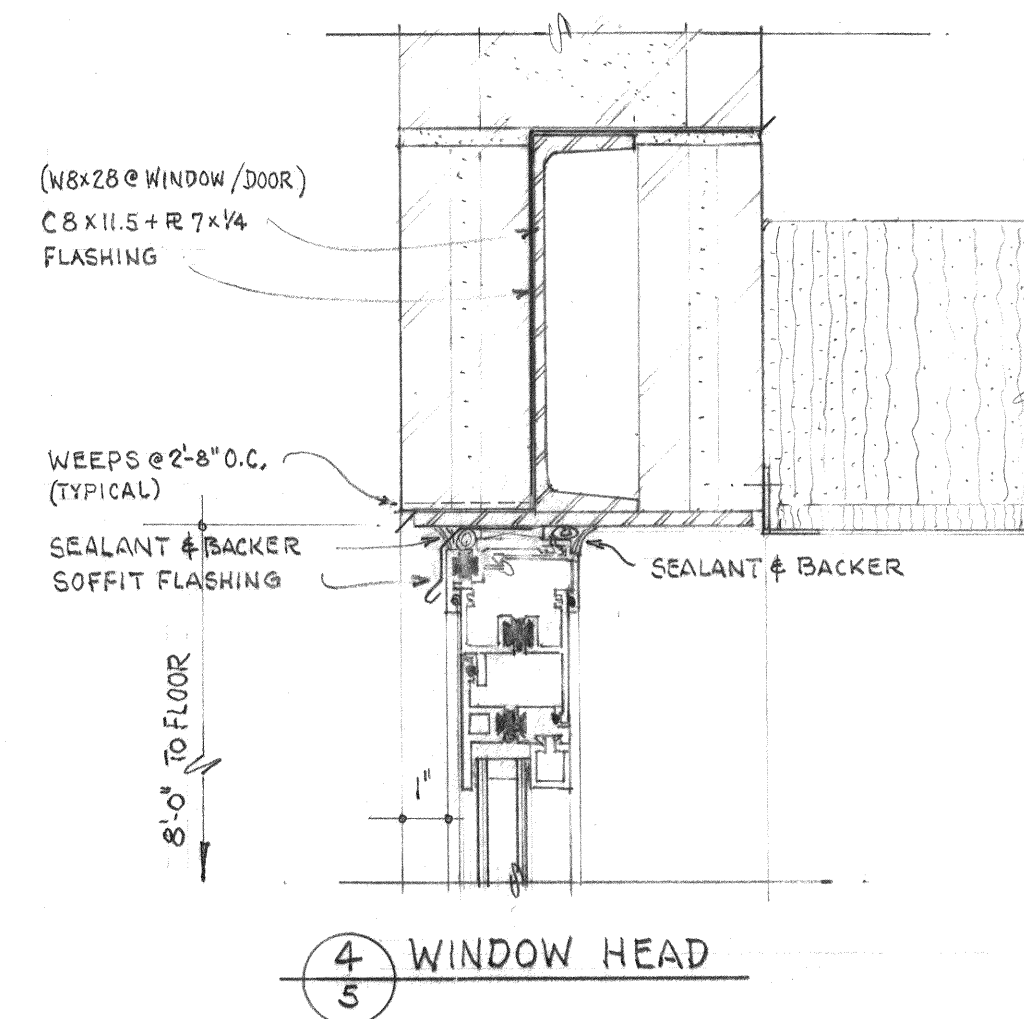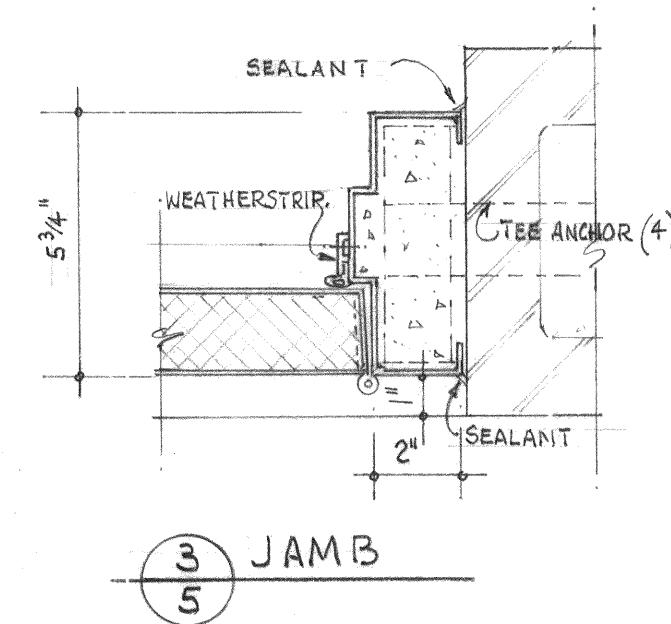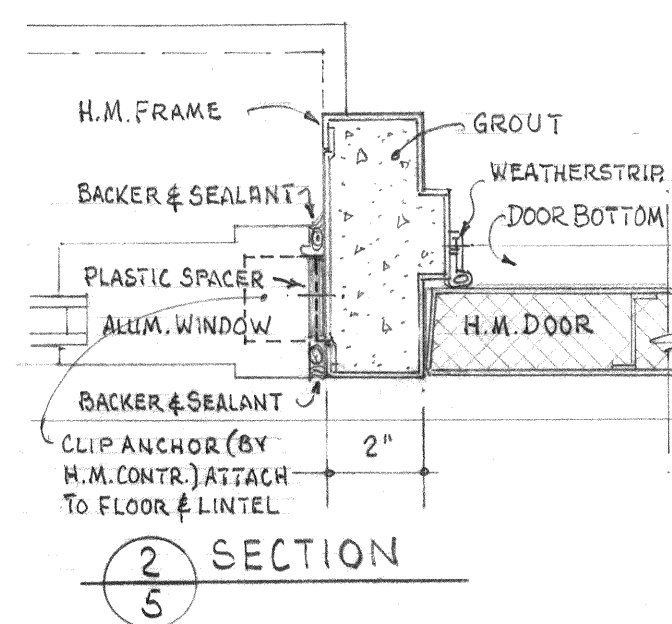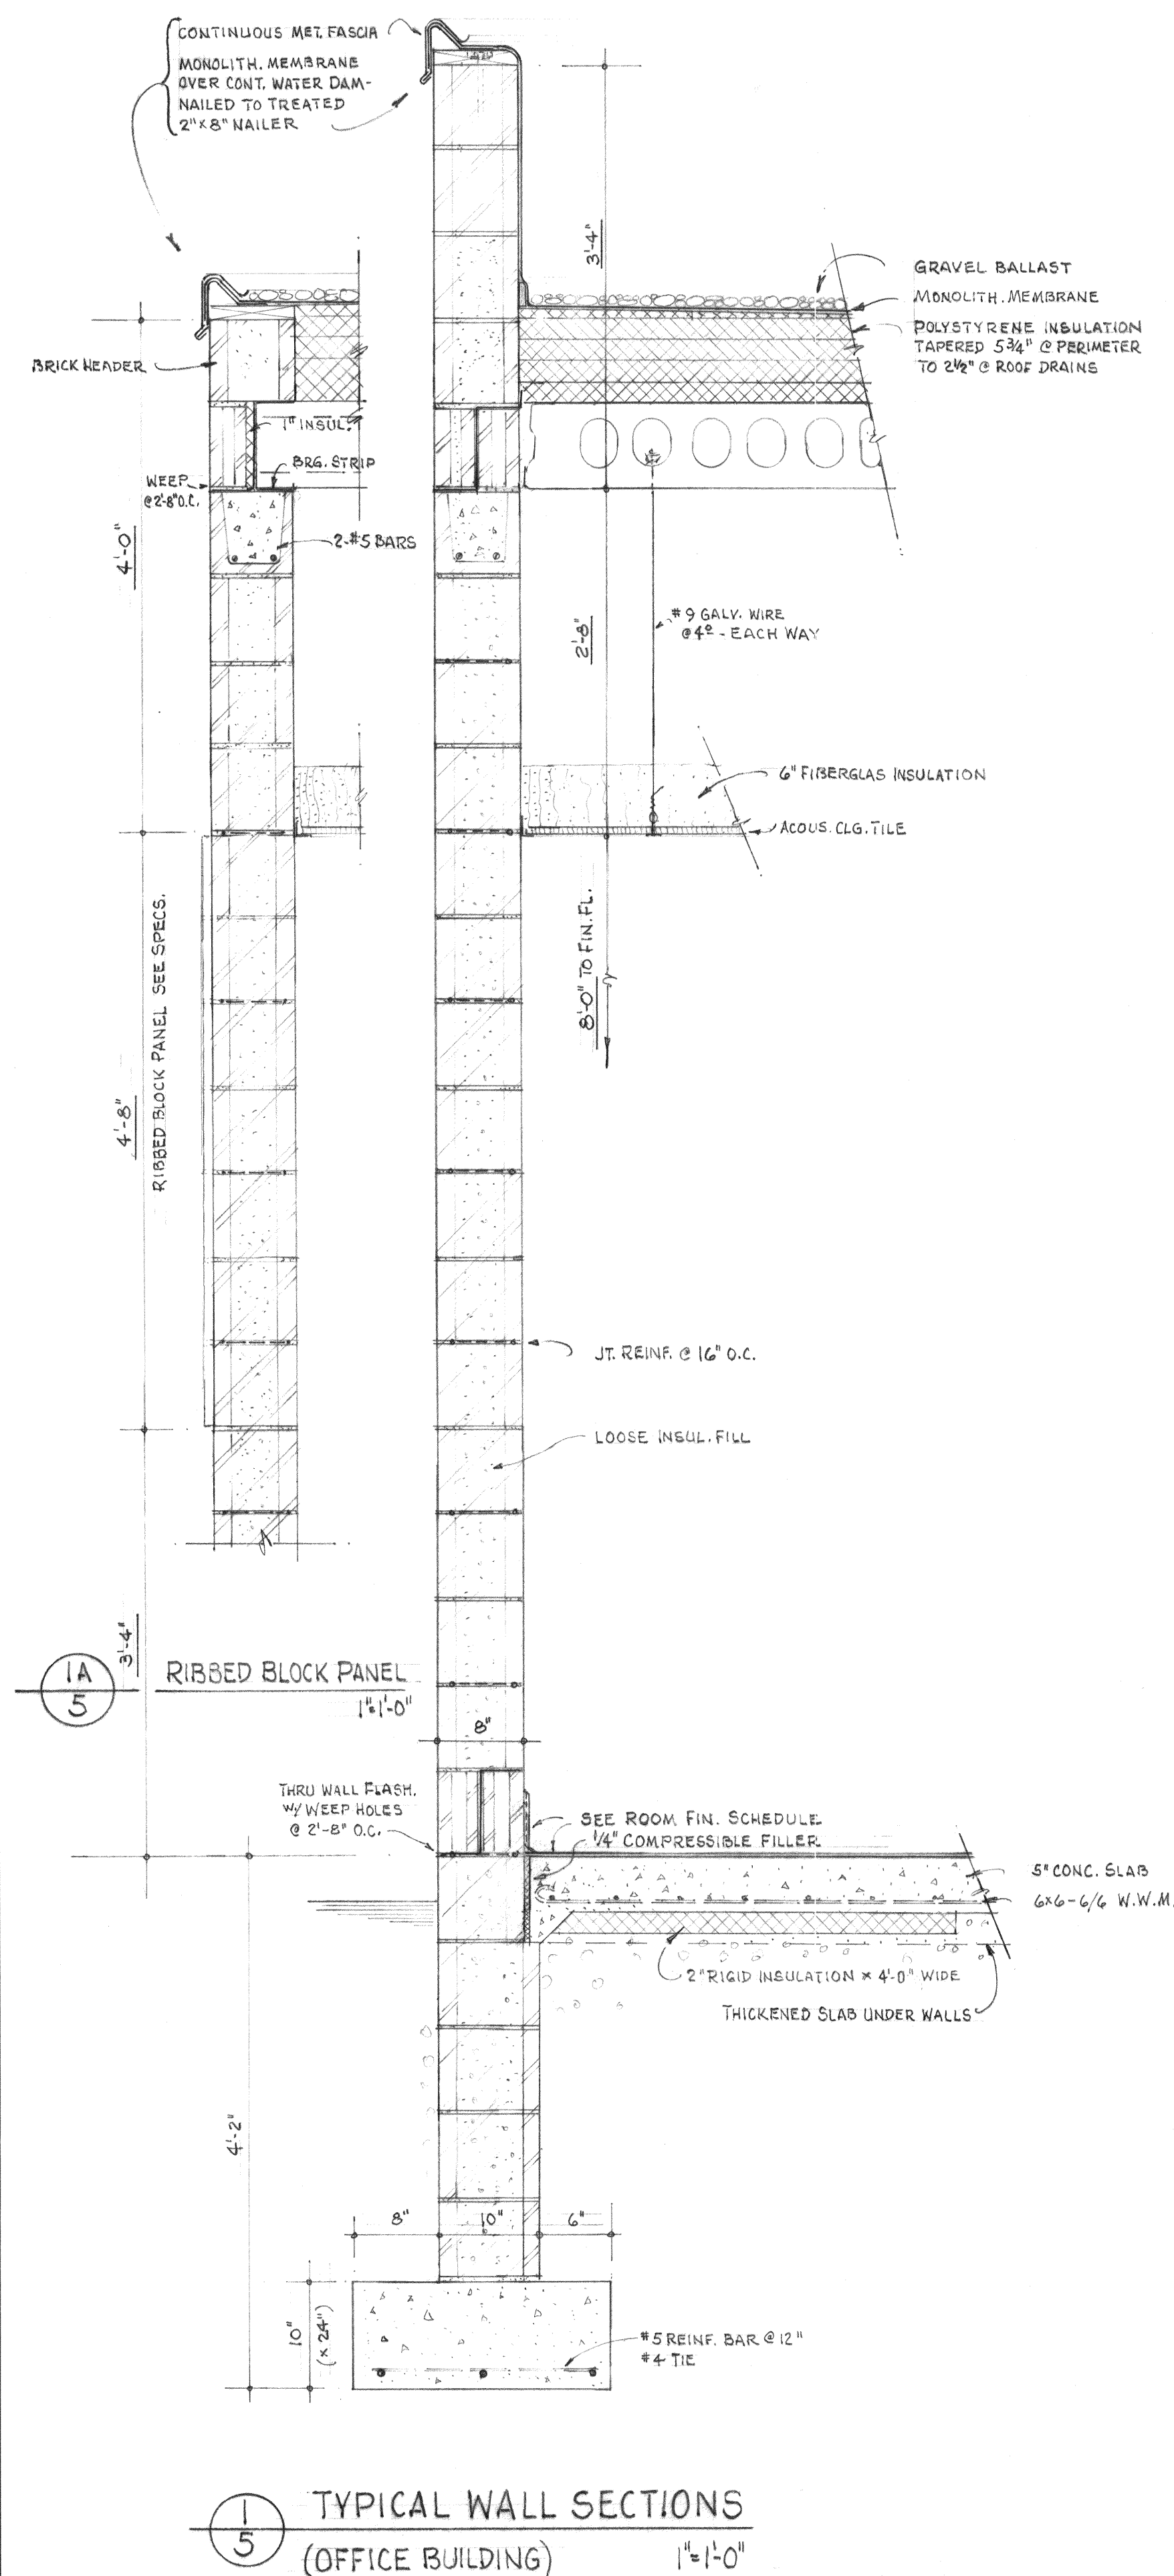


WINDOW & DOOR DETAILS 3'-11-0"

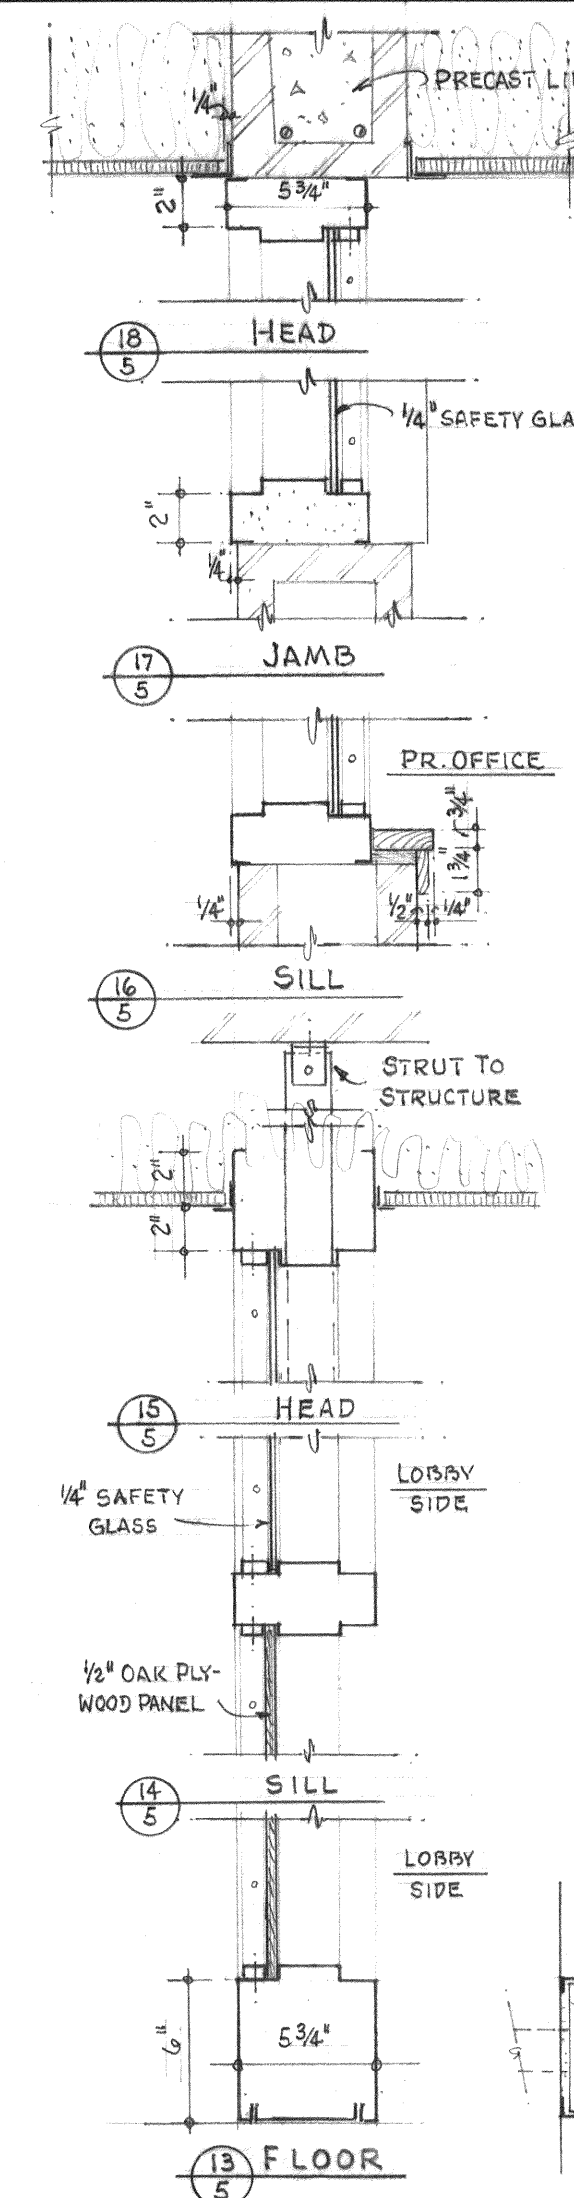


LEGEND		
SYMBOL	ABBR.	DESCRIPTION
		SUPPLY AIR DUCT (UP)
		OUTSIDE AIR DUCT (UP)
		SUPPLY OR OUTSIDE AIR DUCT (DOWN)
		EXHAUST AIR DUCT (UP)
		RETURN AIR DUCT (UP)
		EXHAUST OR RETURN DUCT (DOWN)
		ACOUSTICALLY LINED DUCT
		FLEXIBLE CONNECTION
		VOLUME CONTROL DAMPER
	MOD.	MOTOR OPERATED DAMPER
	F.D.	FIRE DAMPER
		TURNING VANES
		DEFLECTOR
		INCLINED RISE, WITH RESPECT TO AIR FLOW
		INCLINED DROP, WITH RESPECT TO AIR FLOW
		DUCT SIZE, 1ST FIGURE - SIDE SHOWN, 2ND FIGURE - SIDE NOT SHOWN
	A.D.	ACCESS DOOR
	E.G.	EXHAUST GRILLE

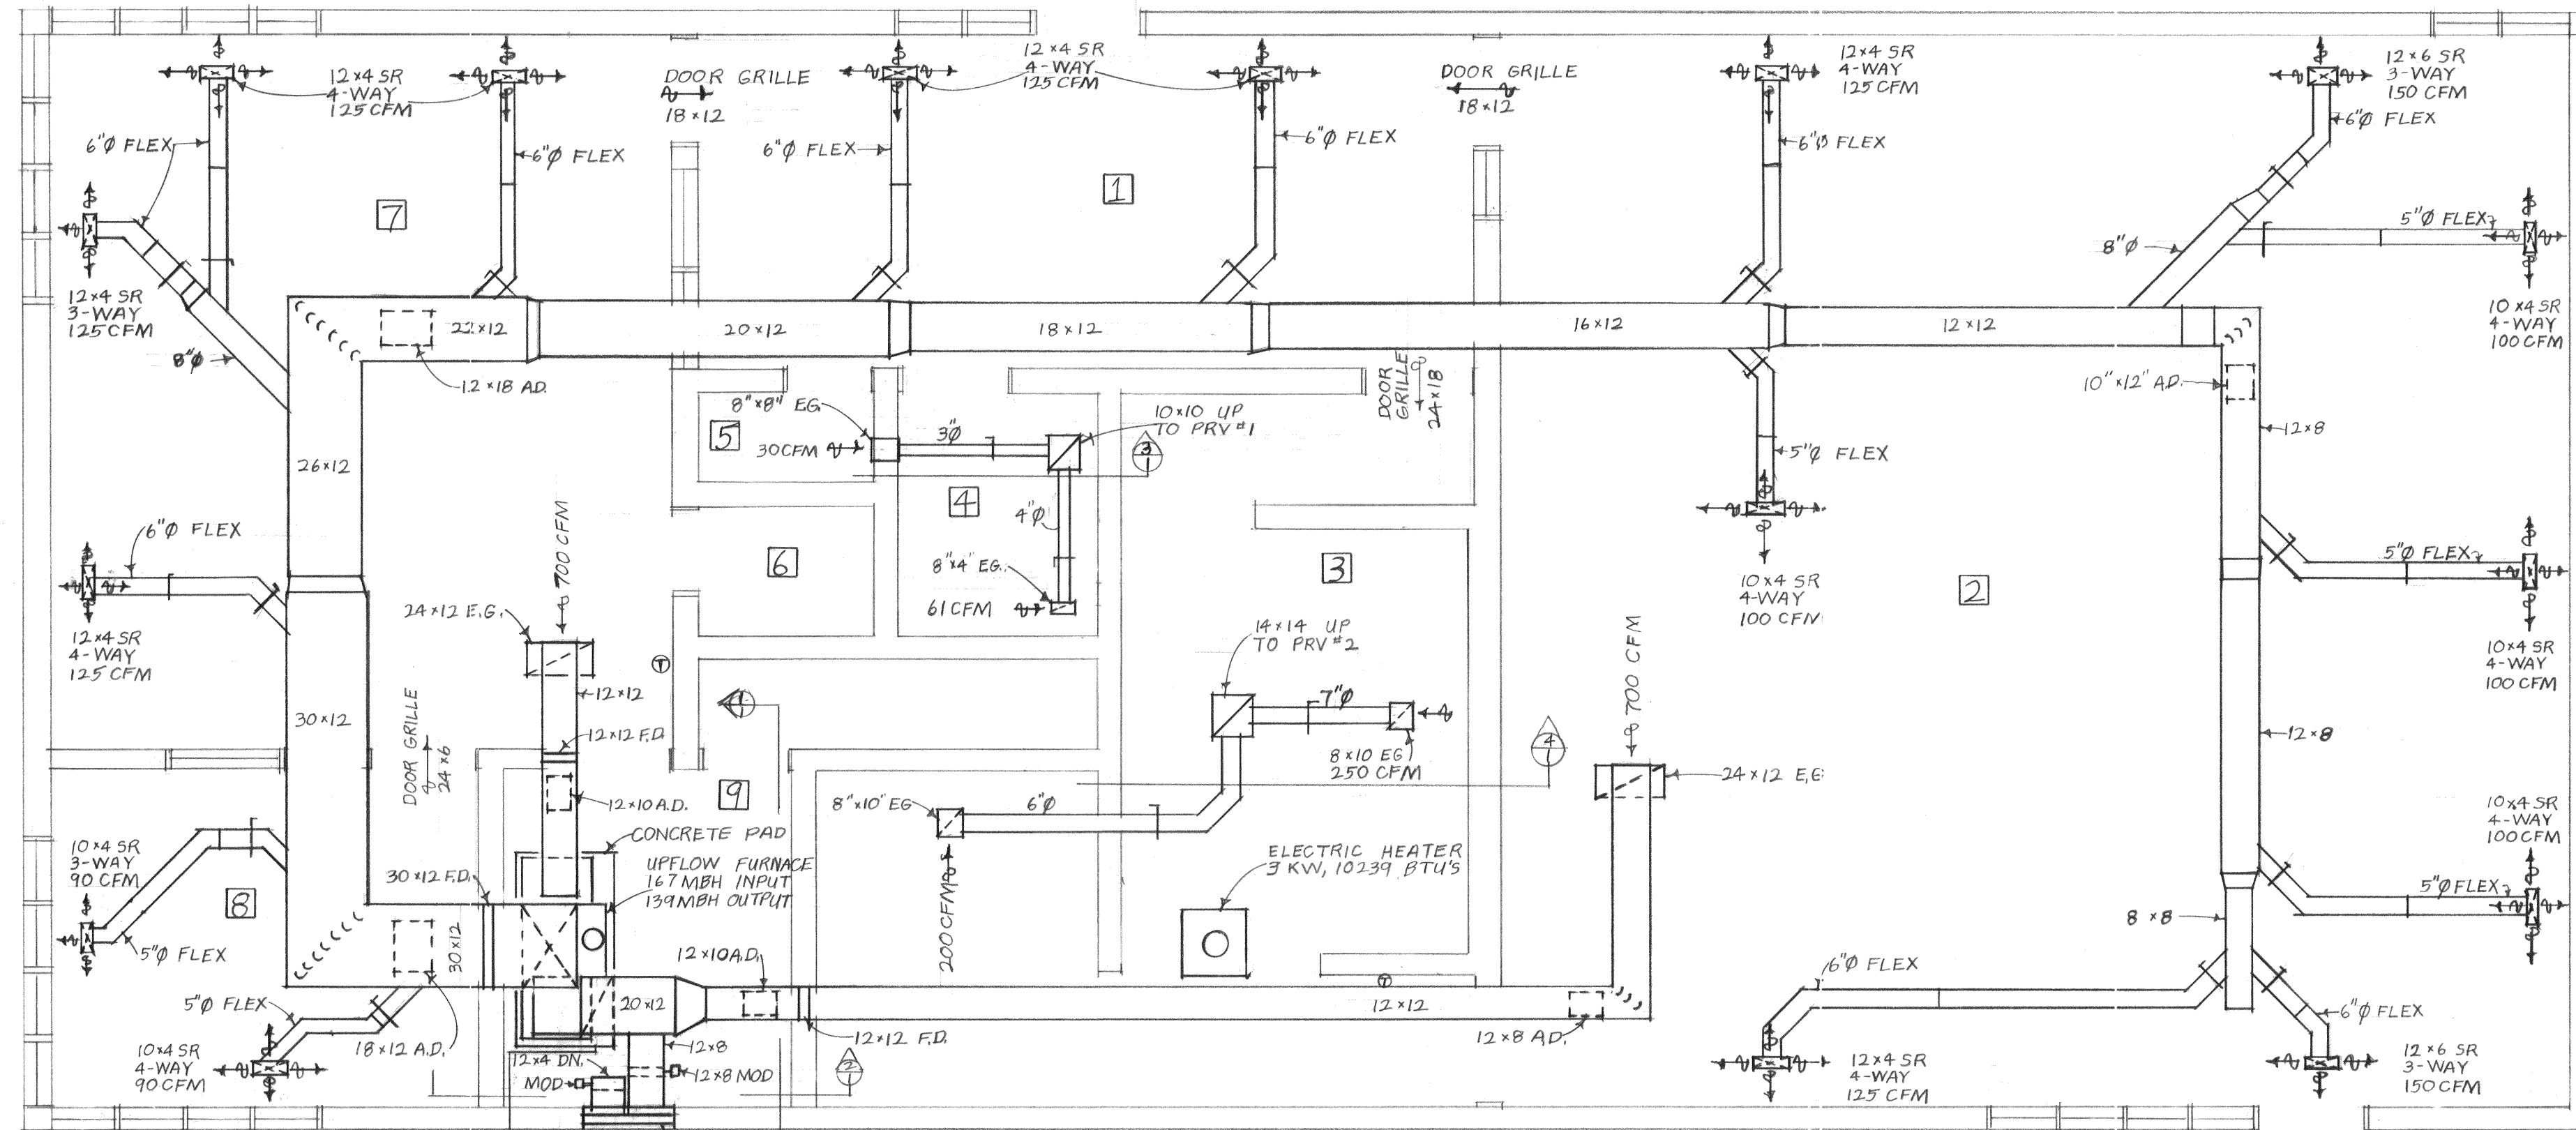


CEILING PLAN
SCALE: 1/4" = 1'-0"

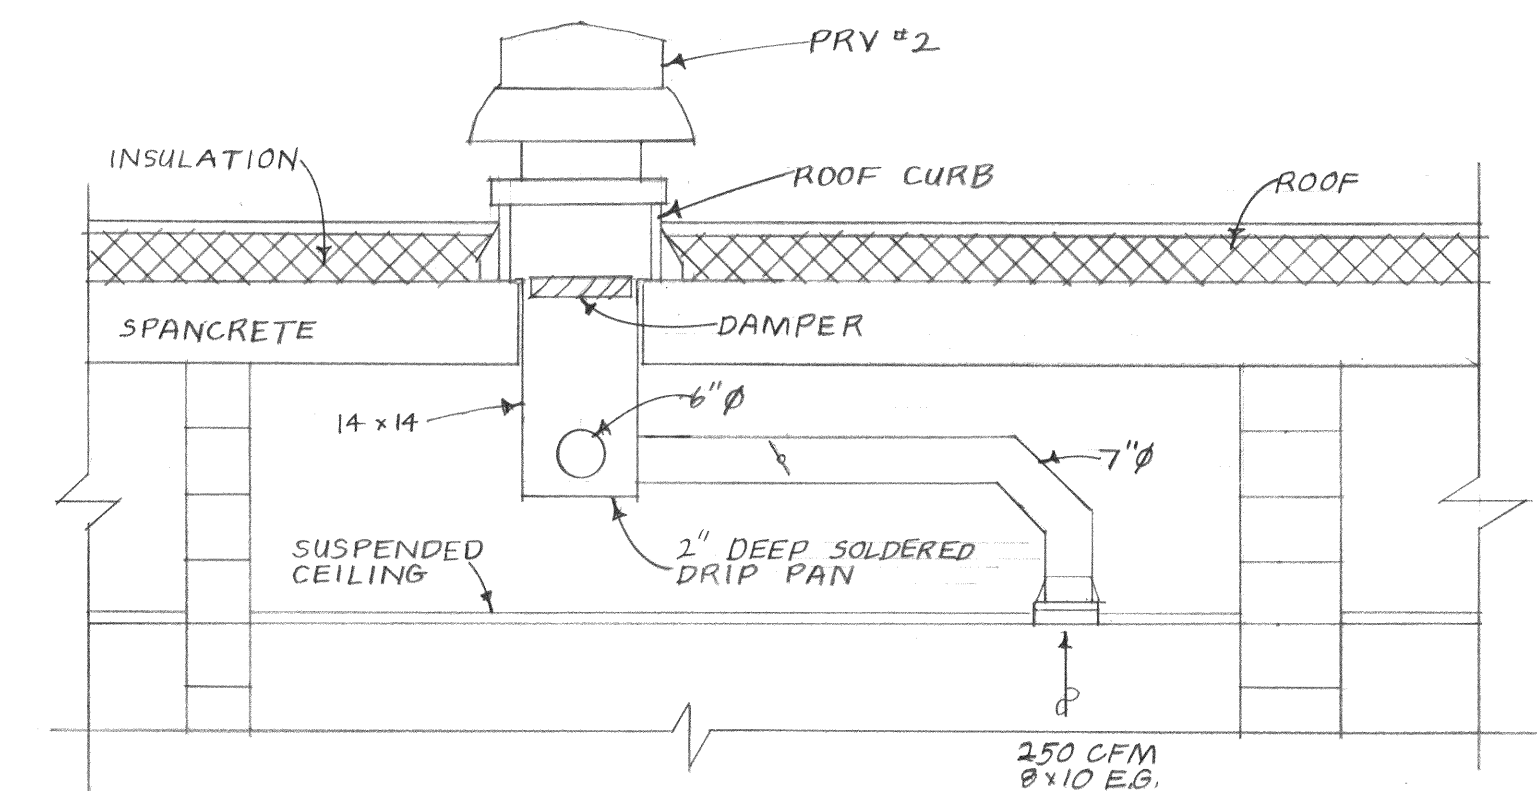


SECTION 4
SCALE: 1/2" = 1'-0"

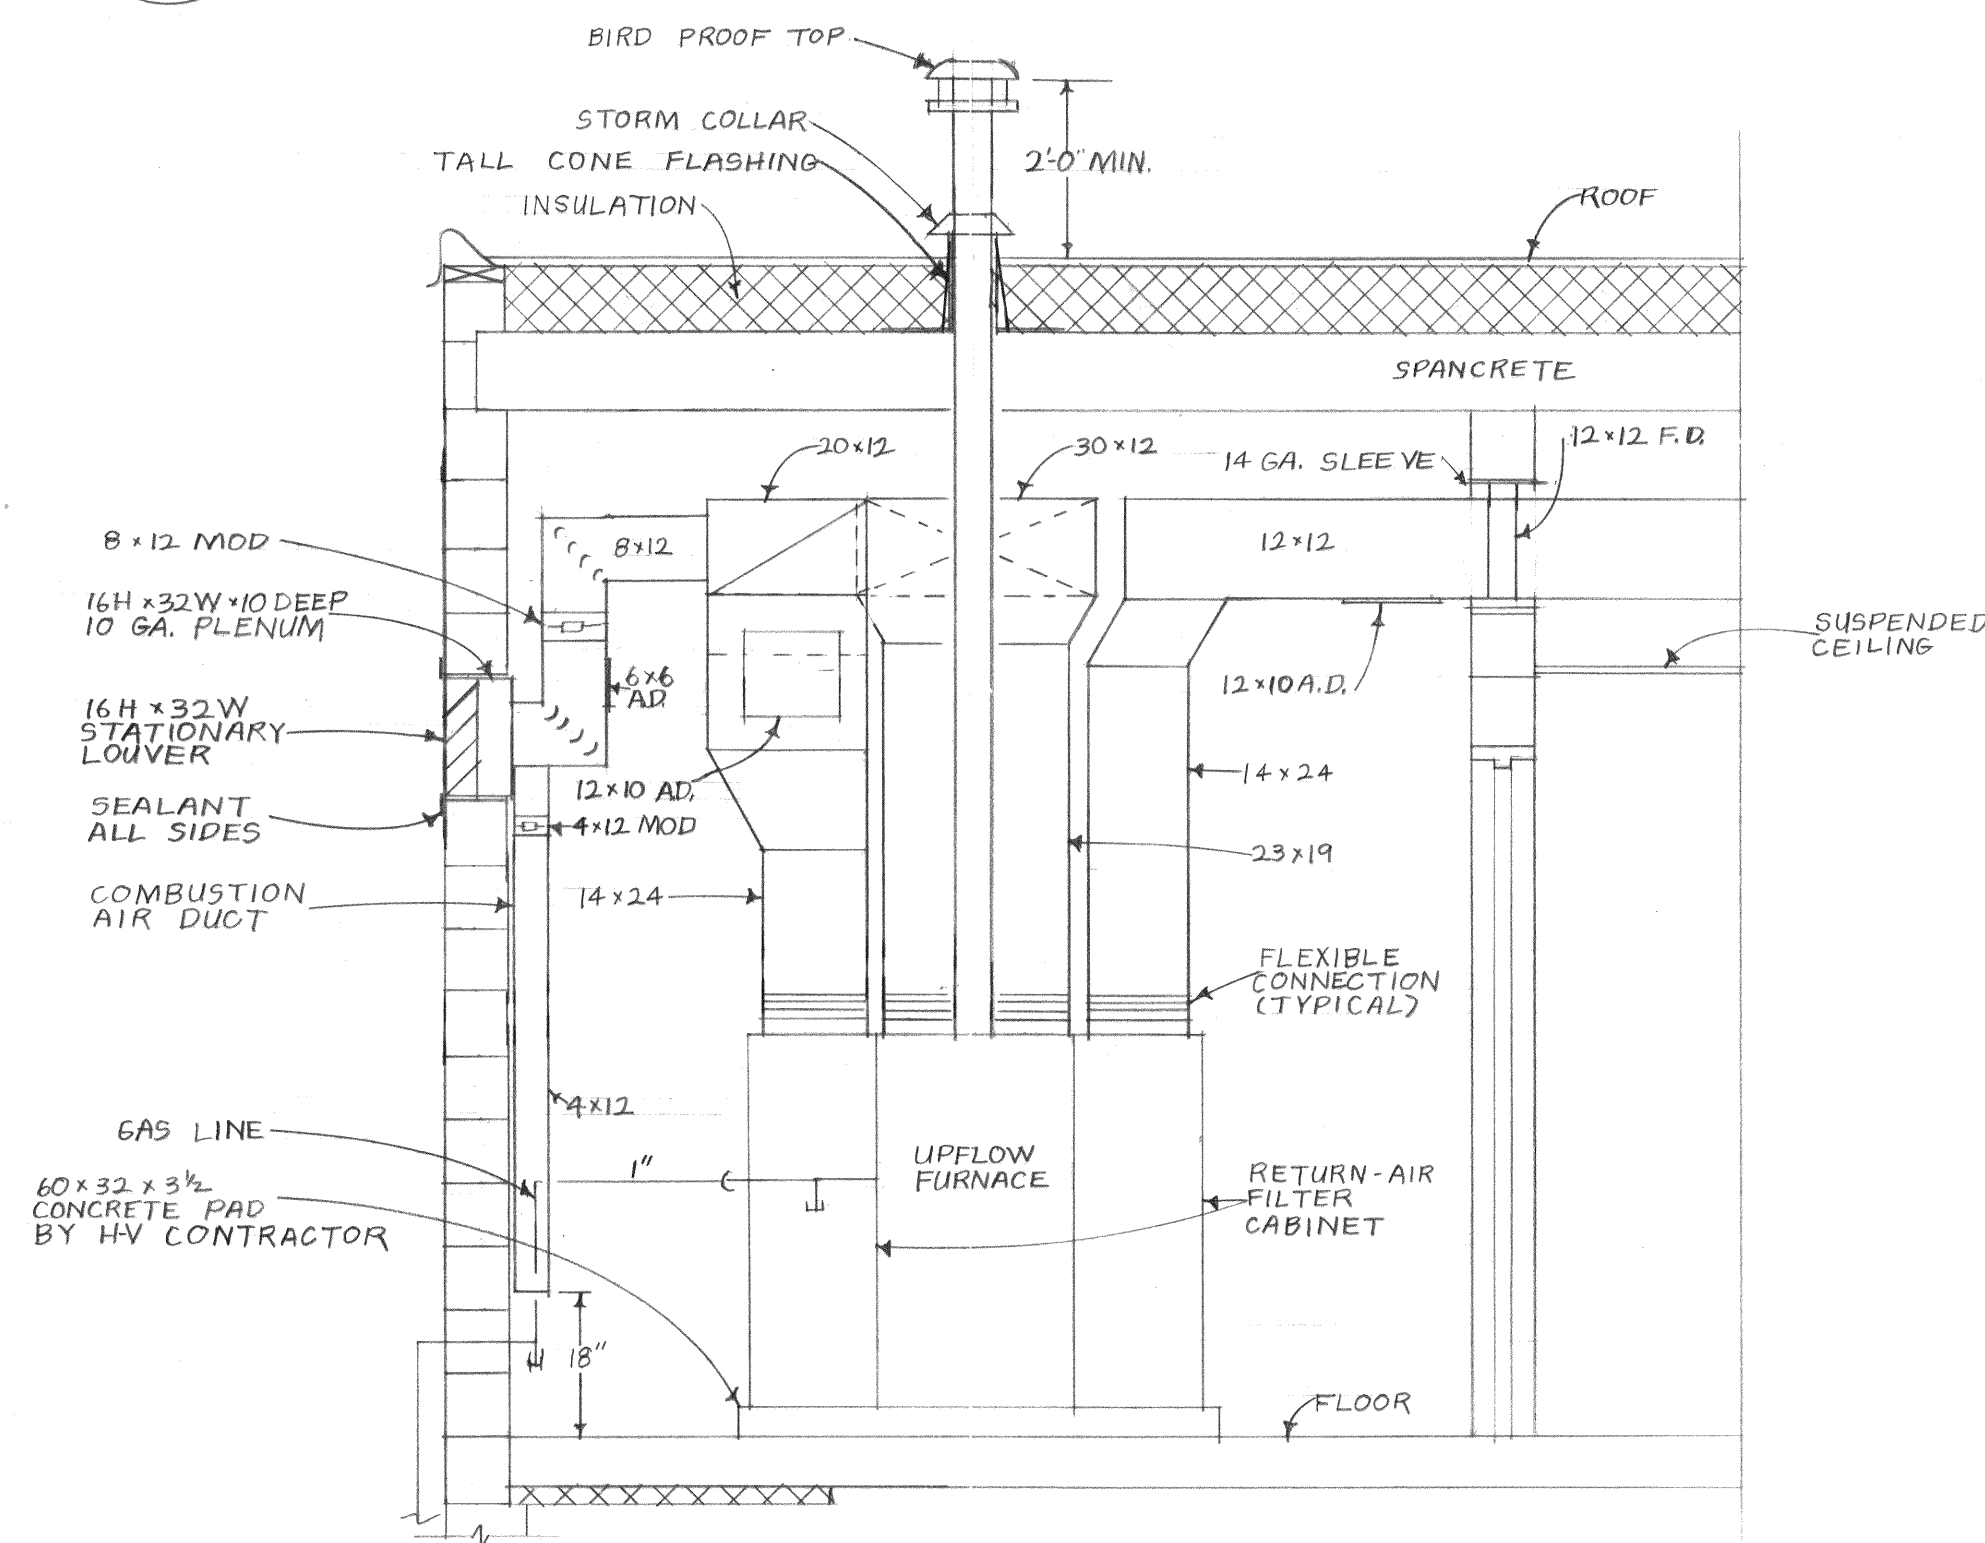


SECTION 1
SCALE: 1/2" = 1'-0"

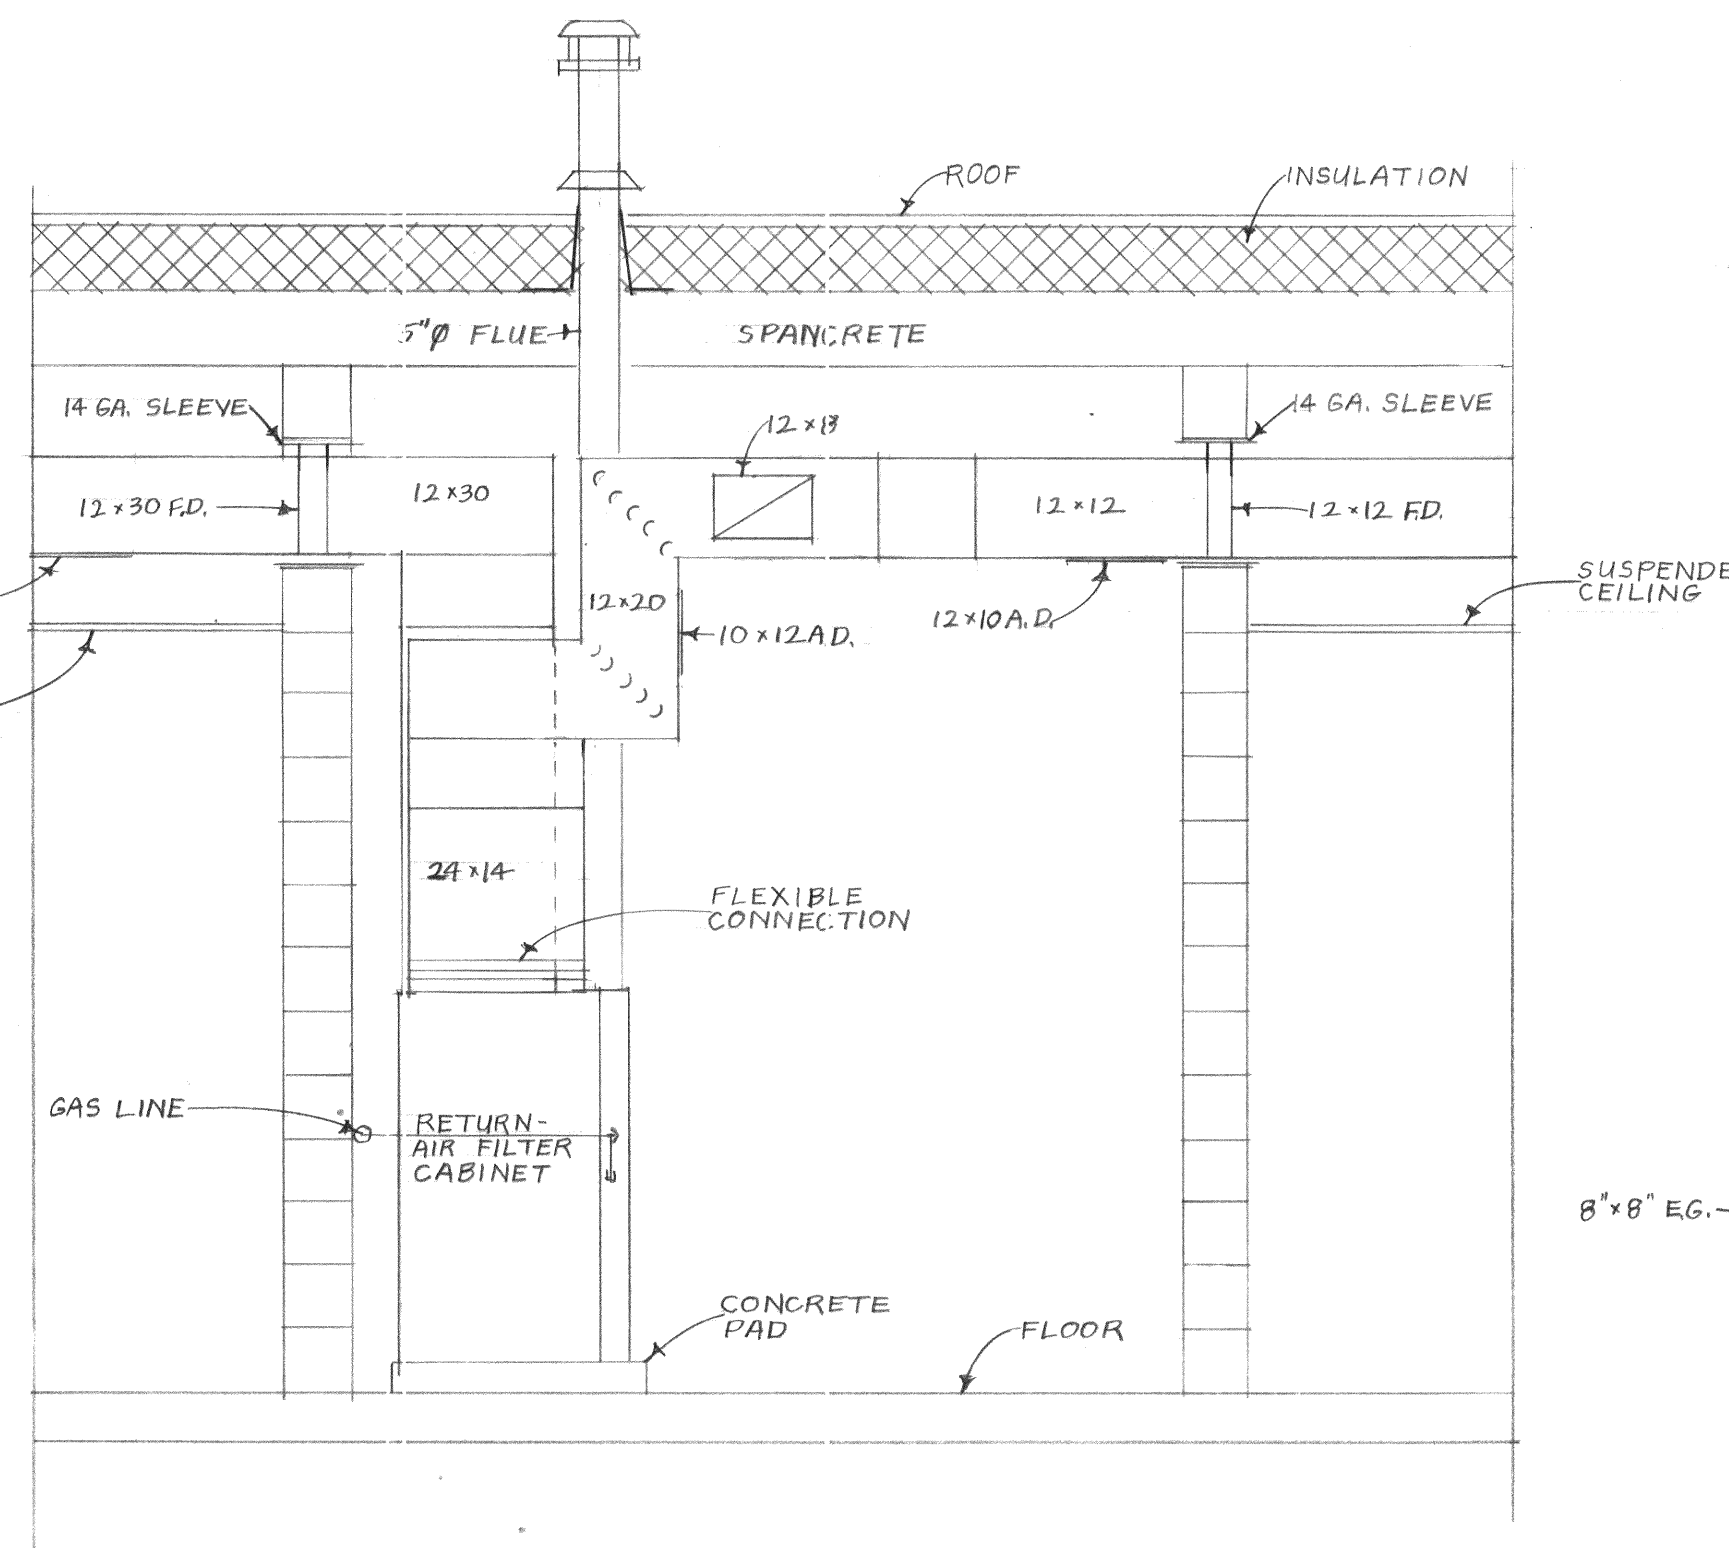

SECTION 2
SCALE: 1/2" = 1'-0"

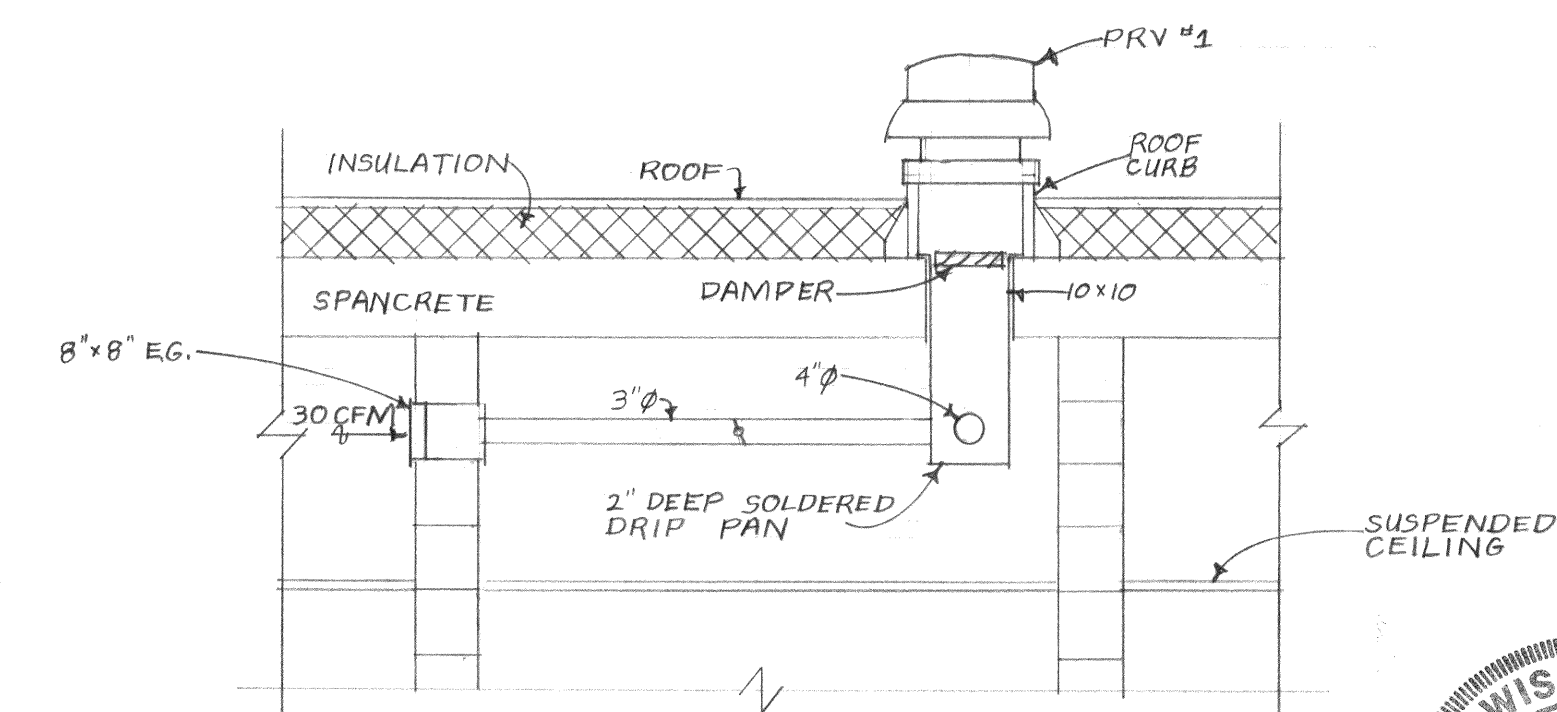

SECTION 3
SCALE: 1/2" = 1'-0"

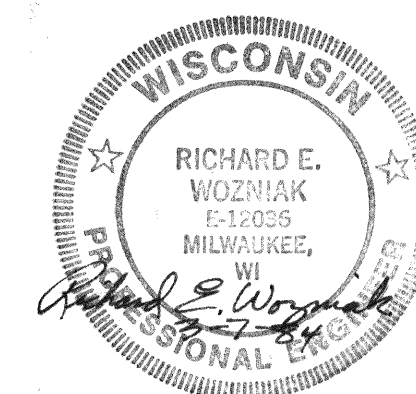

POWER ROOF VENTILATOR SCHEDULE

NO.	AREA SERVED	MODEL	CFM	DAMPER	S.P.	RPM	HP	POWER	REMARKS
1	ROOMS 4 & 5	G	91	BACKDRAFT	1/4	1300	1/60	120/14/60	GREENHECK NO. G-65-G
2	ROOM 3	G	450	BACKDRAFT	1/4	860	1/20	120/14/60	GREENHECK NO. G-120-C

MOTOR OPERATED DAMPER SCHEDULE

ROOM NO.	NO. REQ'D.	SIZE WIDTH×HEIGHT	REMARKS
9	1	12×8	ARROW MODEL OBDPL-507
9	1	12×4	ARROW MODEL OBDPL-507

LOUVER SCHEDULE

ROOM NO.	NO. REQ'D.	SIZE	REMARKS
8	1	32W×16H×4D	ARROW MODEL SCW-2-F

FIRE DAMPER SCHEDULE

ROOM NO.	NO. REQ'D.	DUCT SIZE	MOUNTING	REMARKS
9	1	30×12	VERTICAL	ADVANCE AIR UL-75-B
9	2	12×12	VERTICAL	ADVANCE AIR UL-75-B

ACCESS DOOR SCHEDULE

ROOM NO.	NO. REQ'D.	SIZE	REMARKS
2	1	12×8	ADVANCE AIR MODEL 85A
2	1	10×12	
7	1	12×18	
8	1	12×18	
9	1	6×6	
9	3	12×10	

DOOR GRILLE SCHEDULE

ROOM NO.	NO. REQ'D.	SIZE	CFM EACH	TYPE	REMARKS
1	2	18×12	250	INVERTED "V"	ANEMOSTAT MODEL NS
3	1	24×18	450		
8	1	24×6	180		

ELECTRIC HEATER SCHEDULE

ROOM NO.	NO. REQ'D.	KW	VOLTAGE	MOUNTING	REMARKS
3	1	3KW/0.239 BTU/H	240/14/60	CEILING	MARKEL MODEL H3483

FURNACE SCHEDULE


ROOM NO.	TYPE	INPUT	OUTPUT	RATED CFM @ S.P.	POWER	BLOWER H.P.	REMARKS
9	UPFLOW	167 MBH	139 MBH	1890 @ .5	240/14/60	1/2	BRYANT MODEL 397 H SIZE 060140

SUPPLY REGISTER SCHEDULE


ROOM NO.	NO. REQ'D.	SIZE	CFM EACH	DIFFUSION	TYPE	DAMPER	REMARKS
1	2	12×4	125	4-WAY	ADJUSTABLE CURVED - BLADE	STEEL OPPOSED BLADE	ANEMOSTAT MODEL IC40
2	2	12×4	125	4-WAY			MODEL IC40
2	2	12×6	150	3-WAY			MODEL IC30
2	4	10×4	100	4-WAY			MODEL IC40
7	3	12×4	125	4-WAY			MODEL IC40
7	1	12×4	125	3-WAY			MODEL IC30
8	1	10×4	90	3-WAY			MODEL IC30
8	1	10×4	90	4-WAY			MODEL IC40

RETURN & EXHAUST REGISTER SCHEDULE


ROOM NO.	NO. REQ'D.	SIZE	CFM EACH	TYPE	DAMPER	REMARKS
2	1	24×12	700	1/2"×1/2"×1/2"	STEEL OPPOSED BLADE	ANEMOSTAT MODEL GC50
3	1	8×10	200			
3	1	8×10	250			
4	1	8×4	61			
5	1	8×8	30	INVERTED "V"		ANEMOSTAT MODEL NSB0
7	1	24×12	700	1/2"×1/2"×1/2"		ANEMOSTAT MODEL GC50

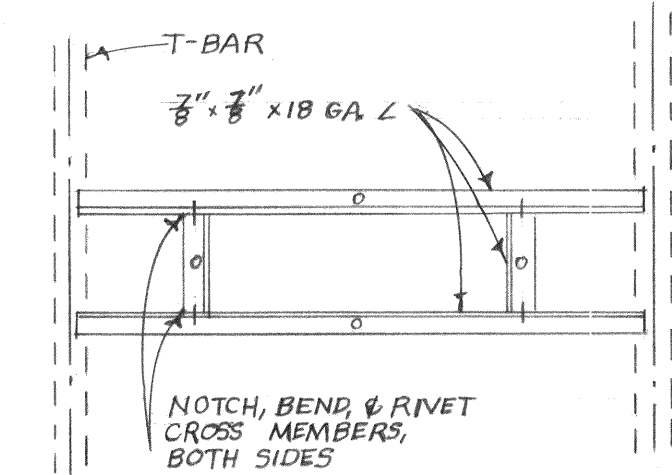


GRILLE SUPPORT ASSEMBLY
NO SCALE

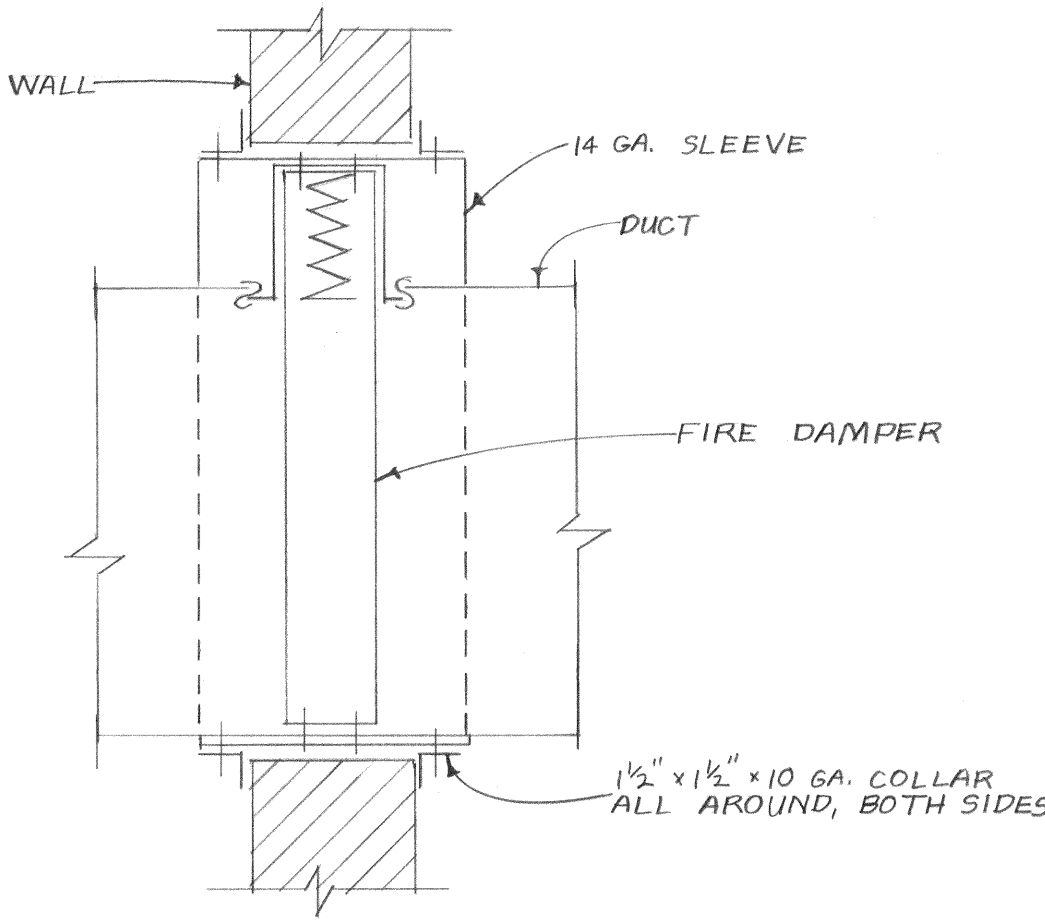


FIRE DAMPER INSTALLATION
NO SCALE

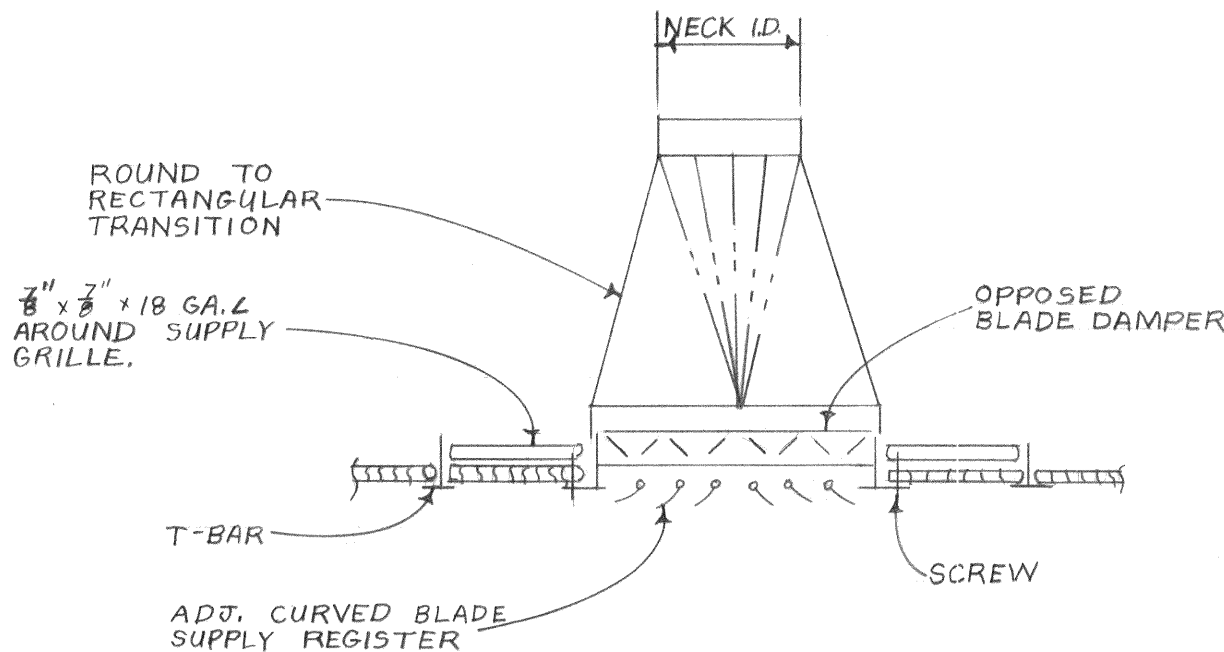


SUPPLY REGISTER INSTALLATION
NO SCALE

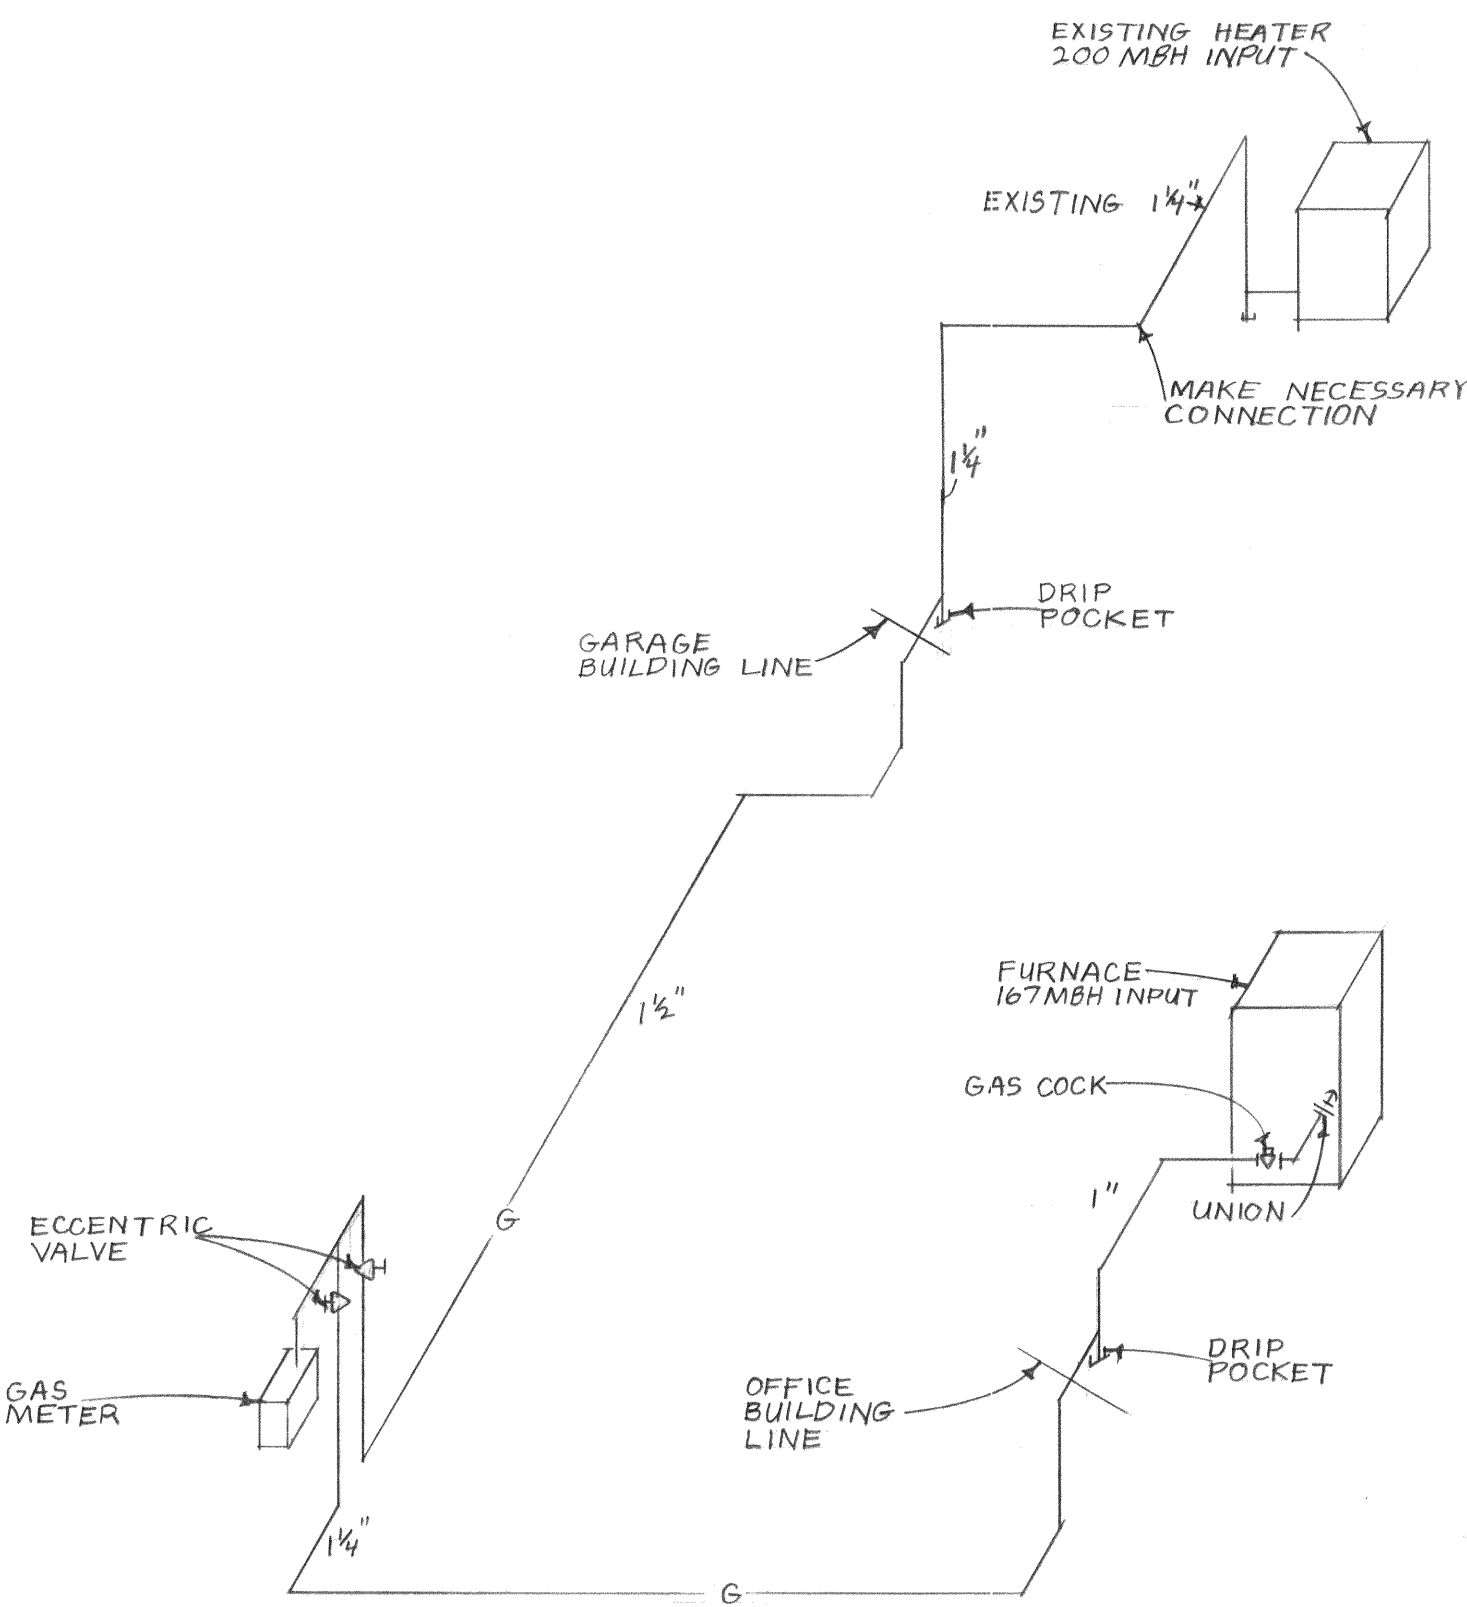


GAS PIPING SCHEMATIC
NO SCALE

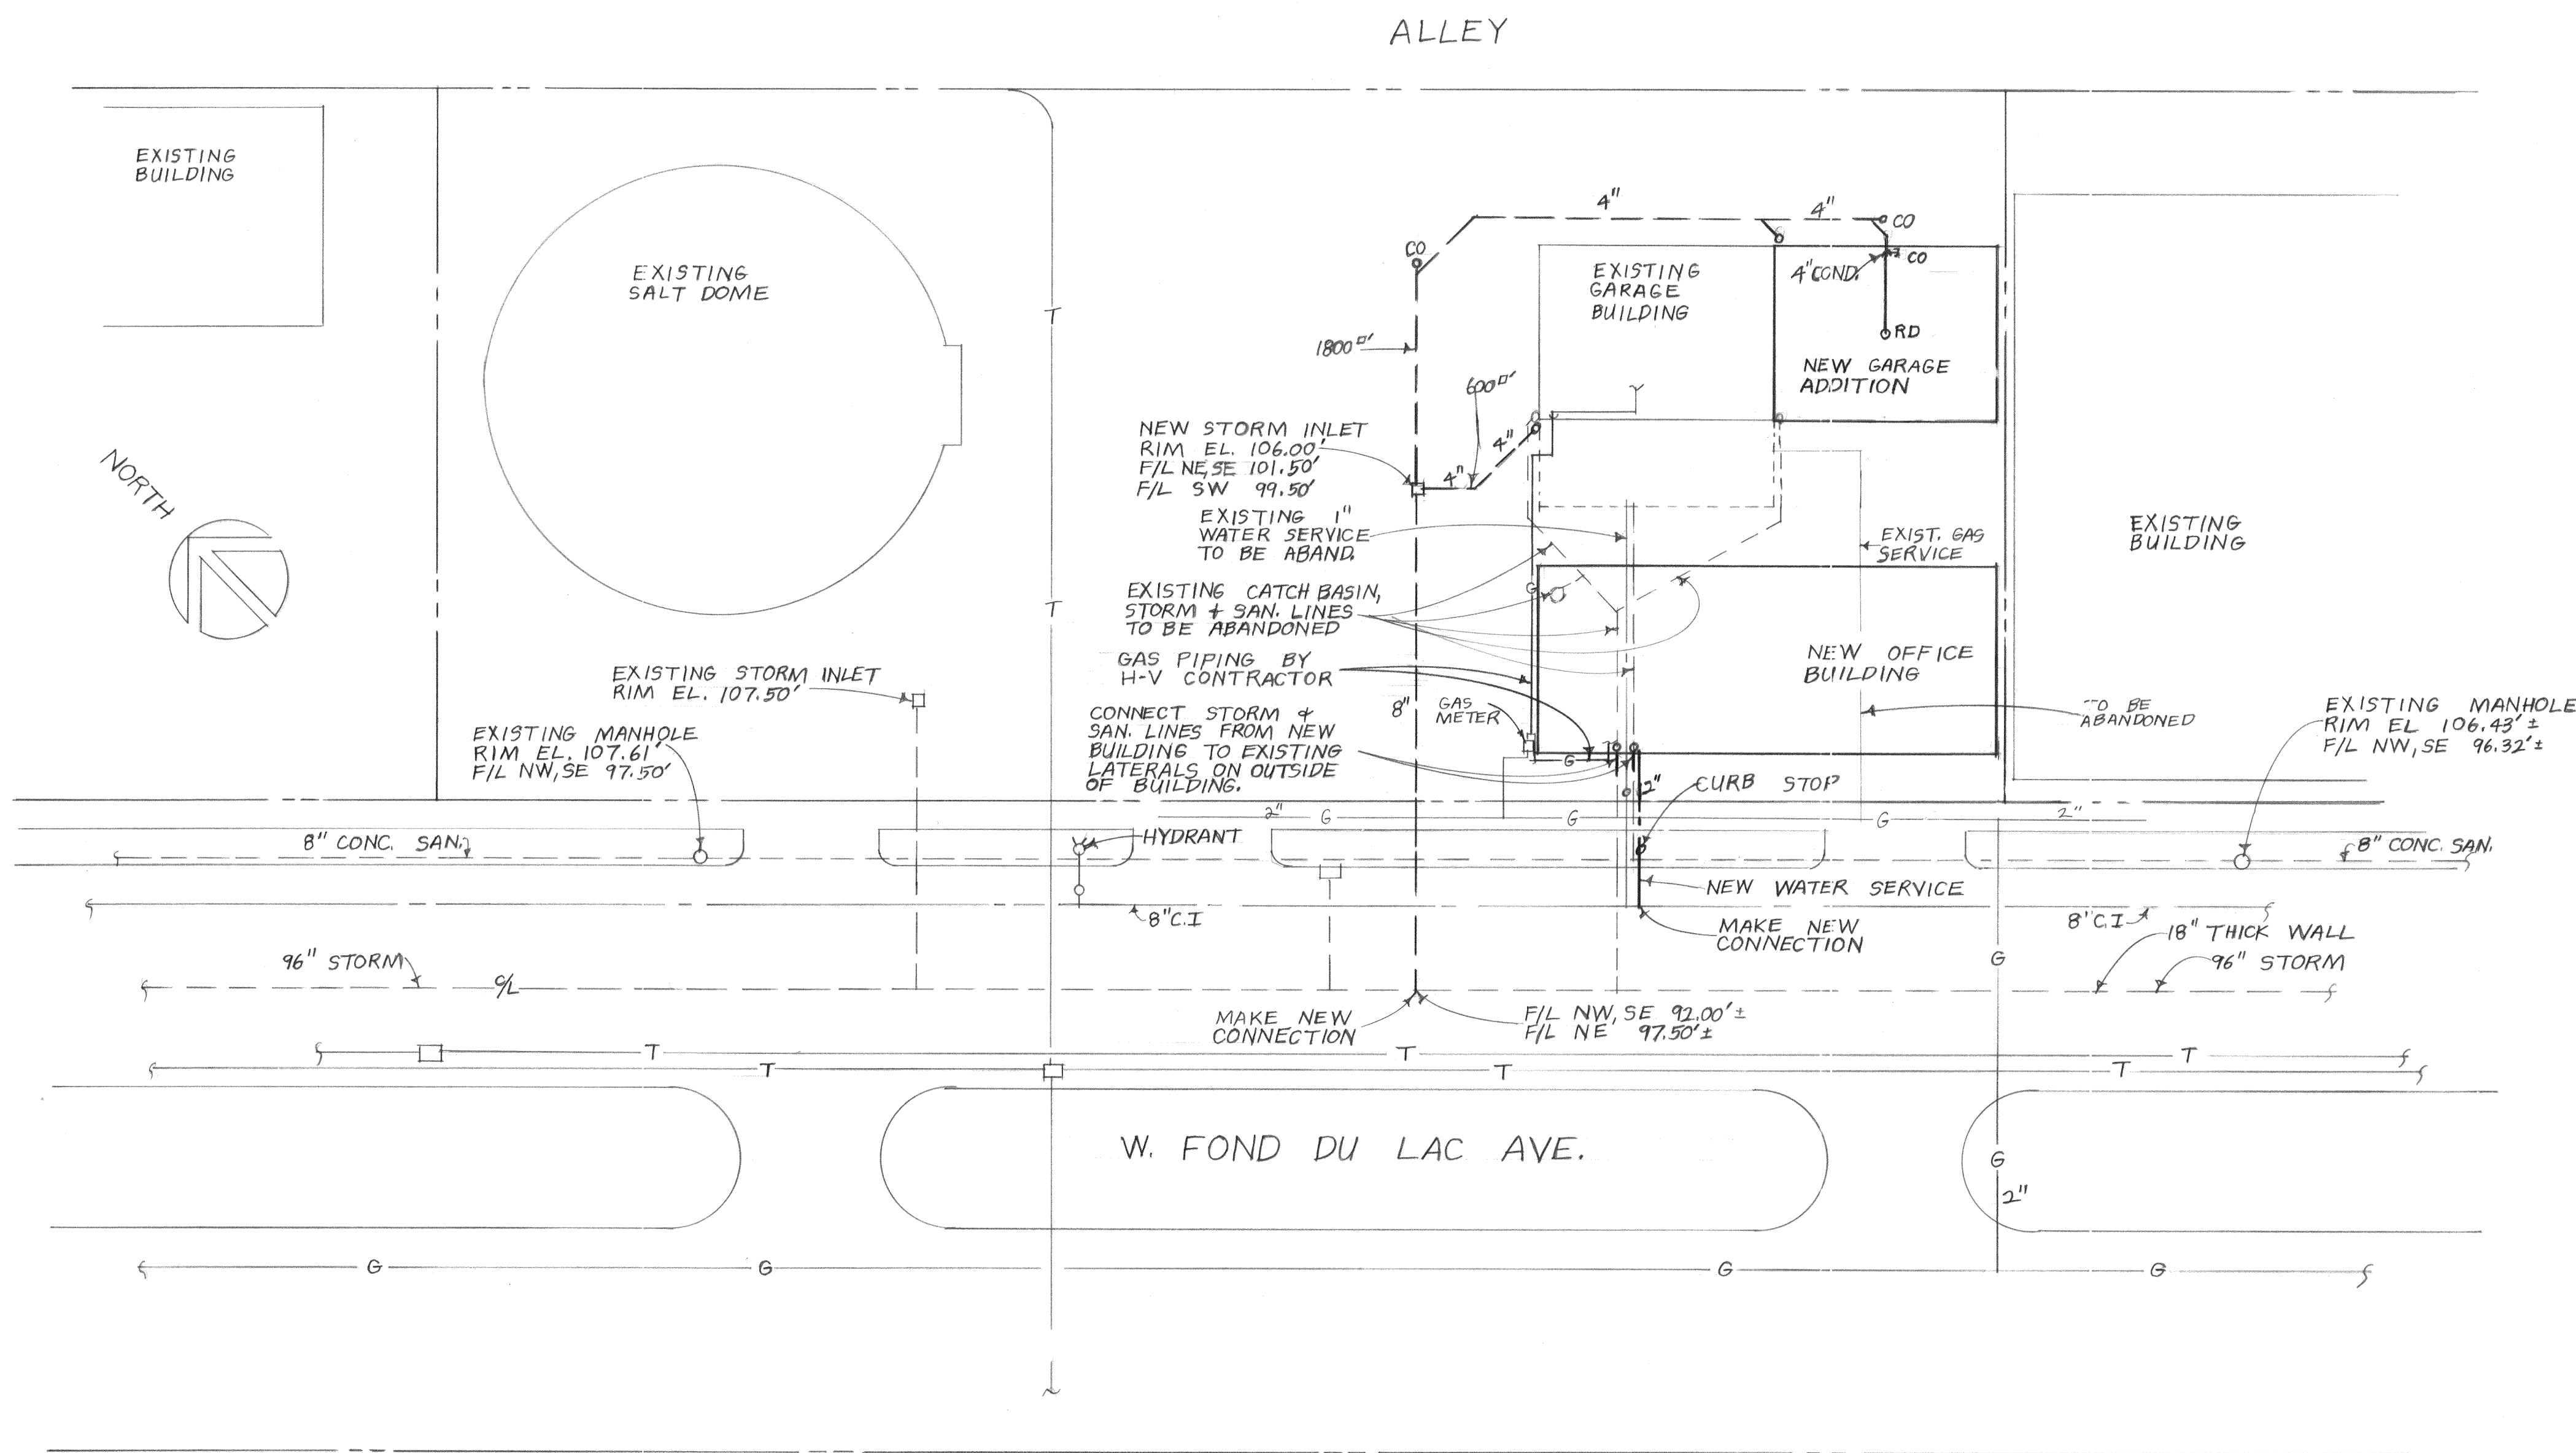

SITE PLAN
SCALE: 1"=20'

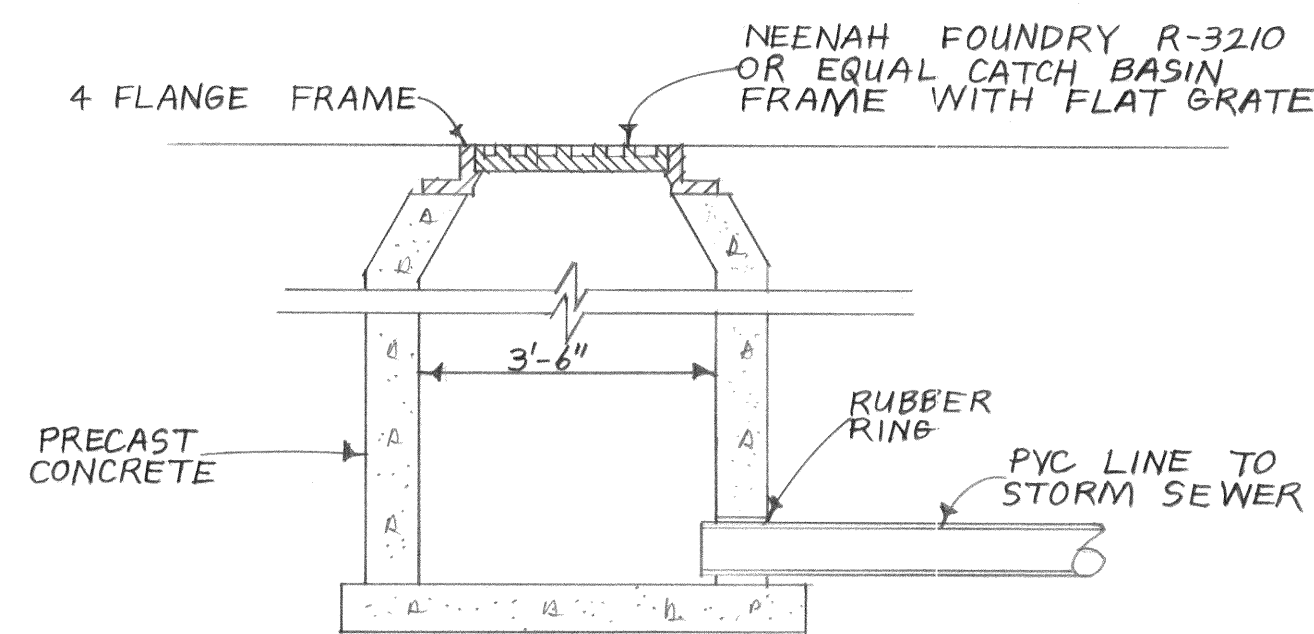

STORM INLET DETAIL
NO SCALE

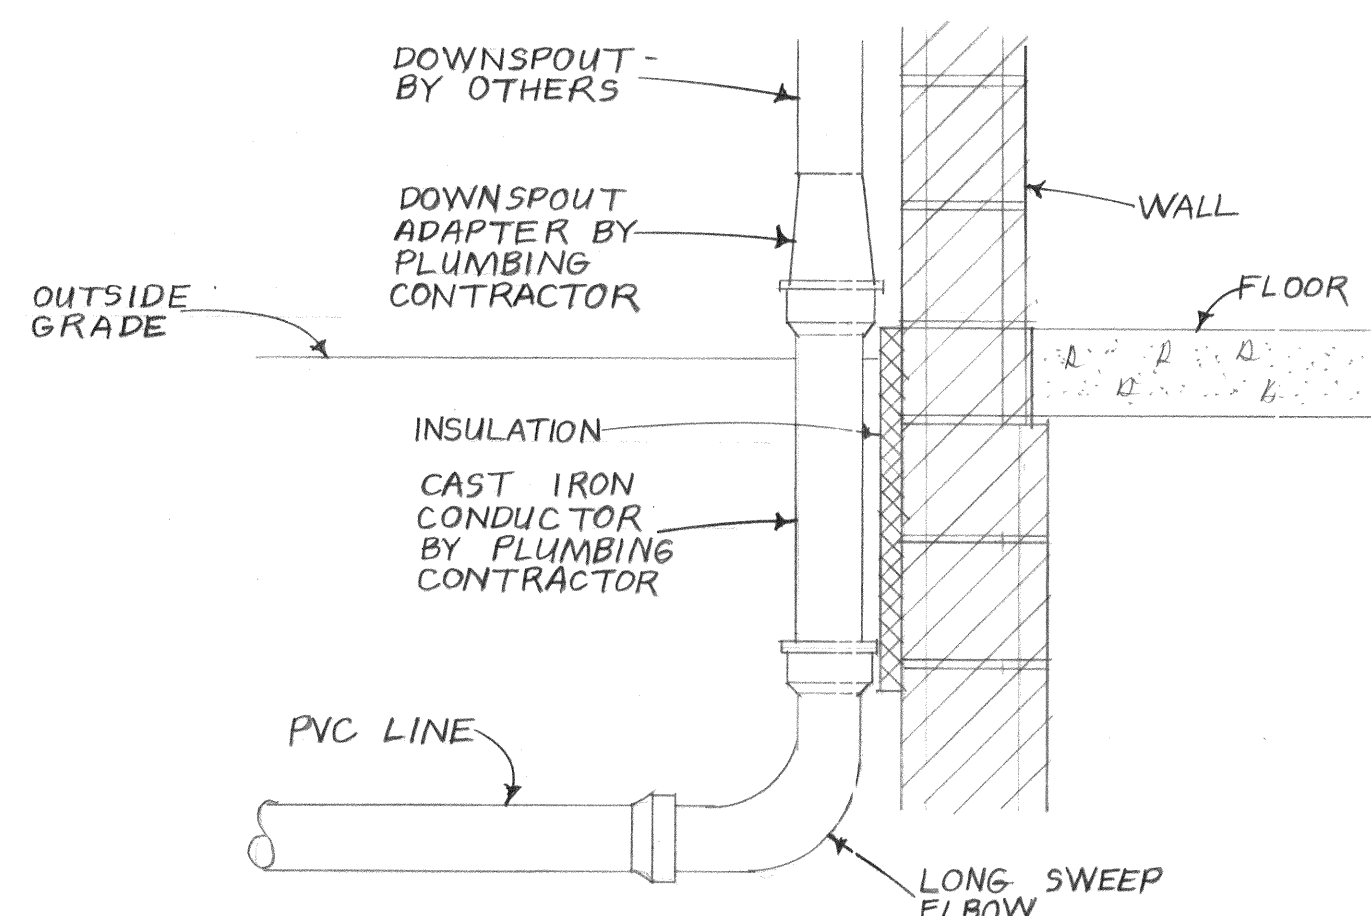

CONDUCTOR DETAIL
NO SCALE

LEGEND		
SYMBOL	ABBR.	DESCRIPTION
---	ST	STORM SEWER PIPING
---	SAN	SANITARY SEWER PIPING
---	COMB	COMBINED SEWER PIPING
---	W	WASTE PIPING (ABOVE GROUND)
---	V	VENT PIPING
---	CWS	COLD WATER SUPPLY
---	HWS	HOT WATER SUPPLY
---	HWR	HOT WATER RETURN

---	G	GAS PIPING
---	BES	BTE & ES STREET LIGHTING UNDERGROUND CABLE
---	F&P	BTE & ES COMMUNICATION UNDERGROUND CABLE
---	T	TELEPHONE CO. UNDERGROUND CABLE
---	E	WEP CO. UNDERGROUND CABLE
---	WU	WESTERN UNION UNDERGROUND CABLE

---		PROPERTY LINE

---		FENCE

---		AIR CHAMBER
---		BALL VALVE
---		CHECK VALVE
---		ECCENTRIC VALVE
---		FIXTURE SUPPLY STOP
---		GATE VALVE
---	O.H.B.	OUTSIDE HOSE BIBB OR DRAIN VALVE
---	WHA.	WATER HAMMER ARRESTER

---	A.D.	AREA DRAIN
---	ALP.	ALUMINUM LIGHT POLE
---	B.D.	BOTTLE DRAIN
---	C.I.	CAST IRON
---	C.O.	CLEAN-OUT
---	CONC.	CONCRETE
---	CLP.	CONCRETE LIGHT POLE
---	COND.	CONDUCTOR
---	D.F.	DRINKING FOUNTAIN
---	DT.	DRAIN TILE
---	D.I.	DUCTILE IRON
---	EWC.	ELECTRIC WATER COOLER
---	EL.	ELEVATION
---	F.U.	FIXTURE UNIT
---	FUV.	FIXTURE UNIT VALVE
---	F.D.	FLOOR DRAIN
---	F.S.	FLOOR SINK
---	F/L	FLOW LINE
---	HYD.	HYDRANT
---	LAV.	LAVATORY
---		PIPING DOWN
---		PIPING UP
---	RD.	ROOF DRAIN
---	SS	SERVICE SINK
---	SHR	SHOWER
---	UR	URINAL
---	VT.	VITRIFIED TILE PIPE
---	W.C.	WATER CLOSET
---	W.P.	WOOD POLE



Department of
Public Works
Bureau of
Bridges and
Public
Buildings

SANITATION FIELD HEADQUARTERS
7222 WEST FOND DU LAC AVENUE
SITE PLAN & DETAILS

REVISIONS

DESIGNED BY
D.C.N.

DRAWN BY
D.C.N.

CHECKED BY
RW

DATE
10-27-83


SCALE
AS NOTED

JOB NUMBER
421-04



SHEET NUMBER
P-1

OF
2




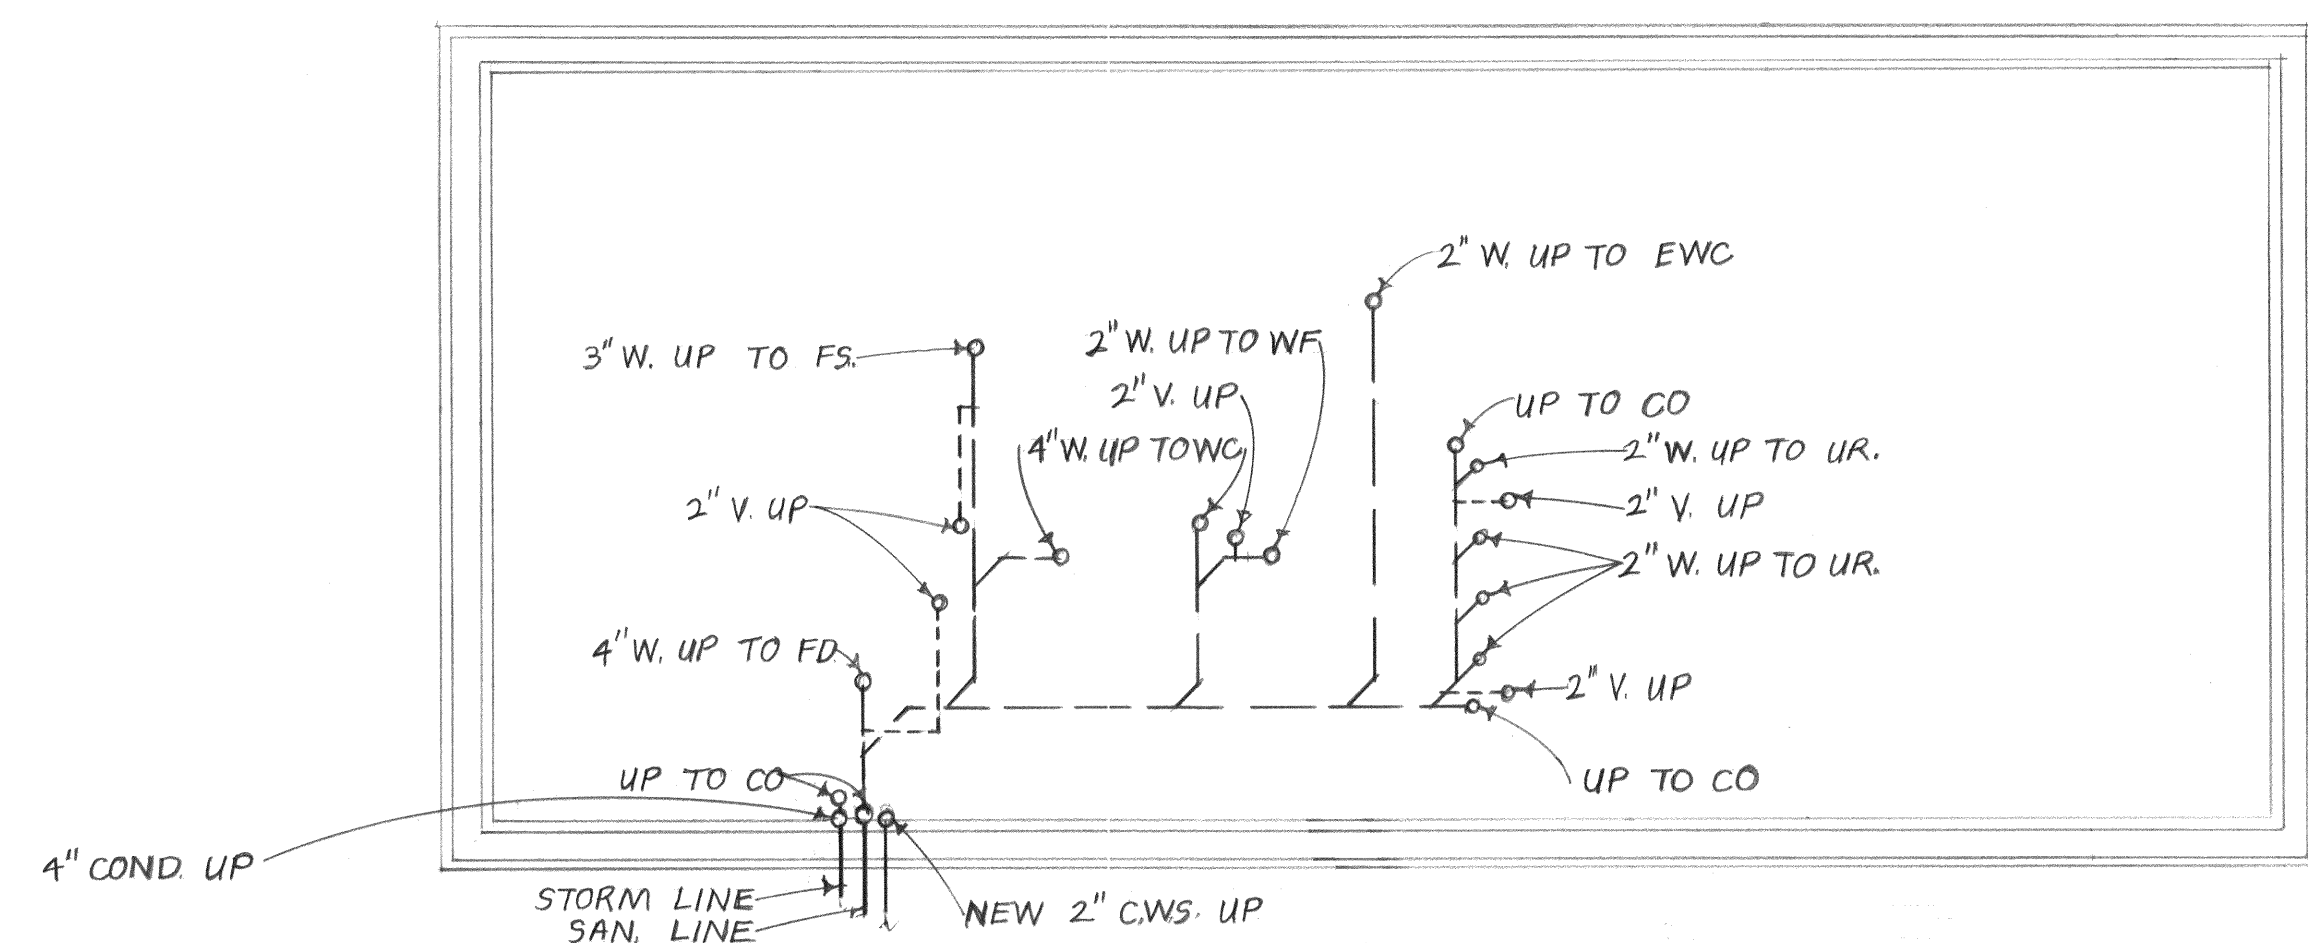


FOUNDATION PLAN
SCALE: 1/8"=1'-0"

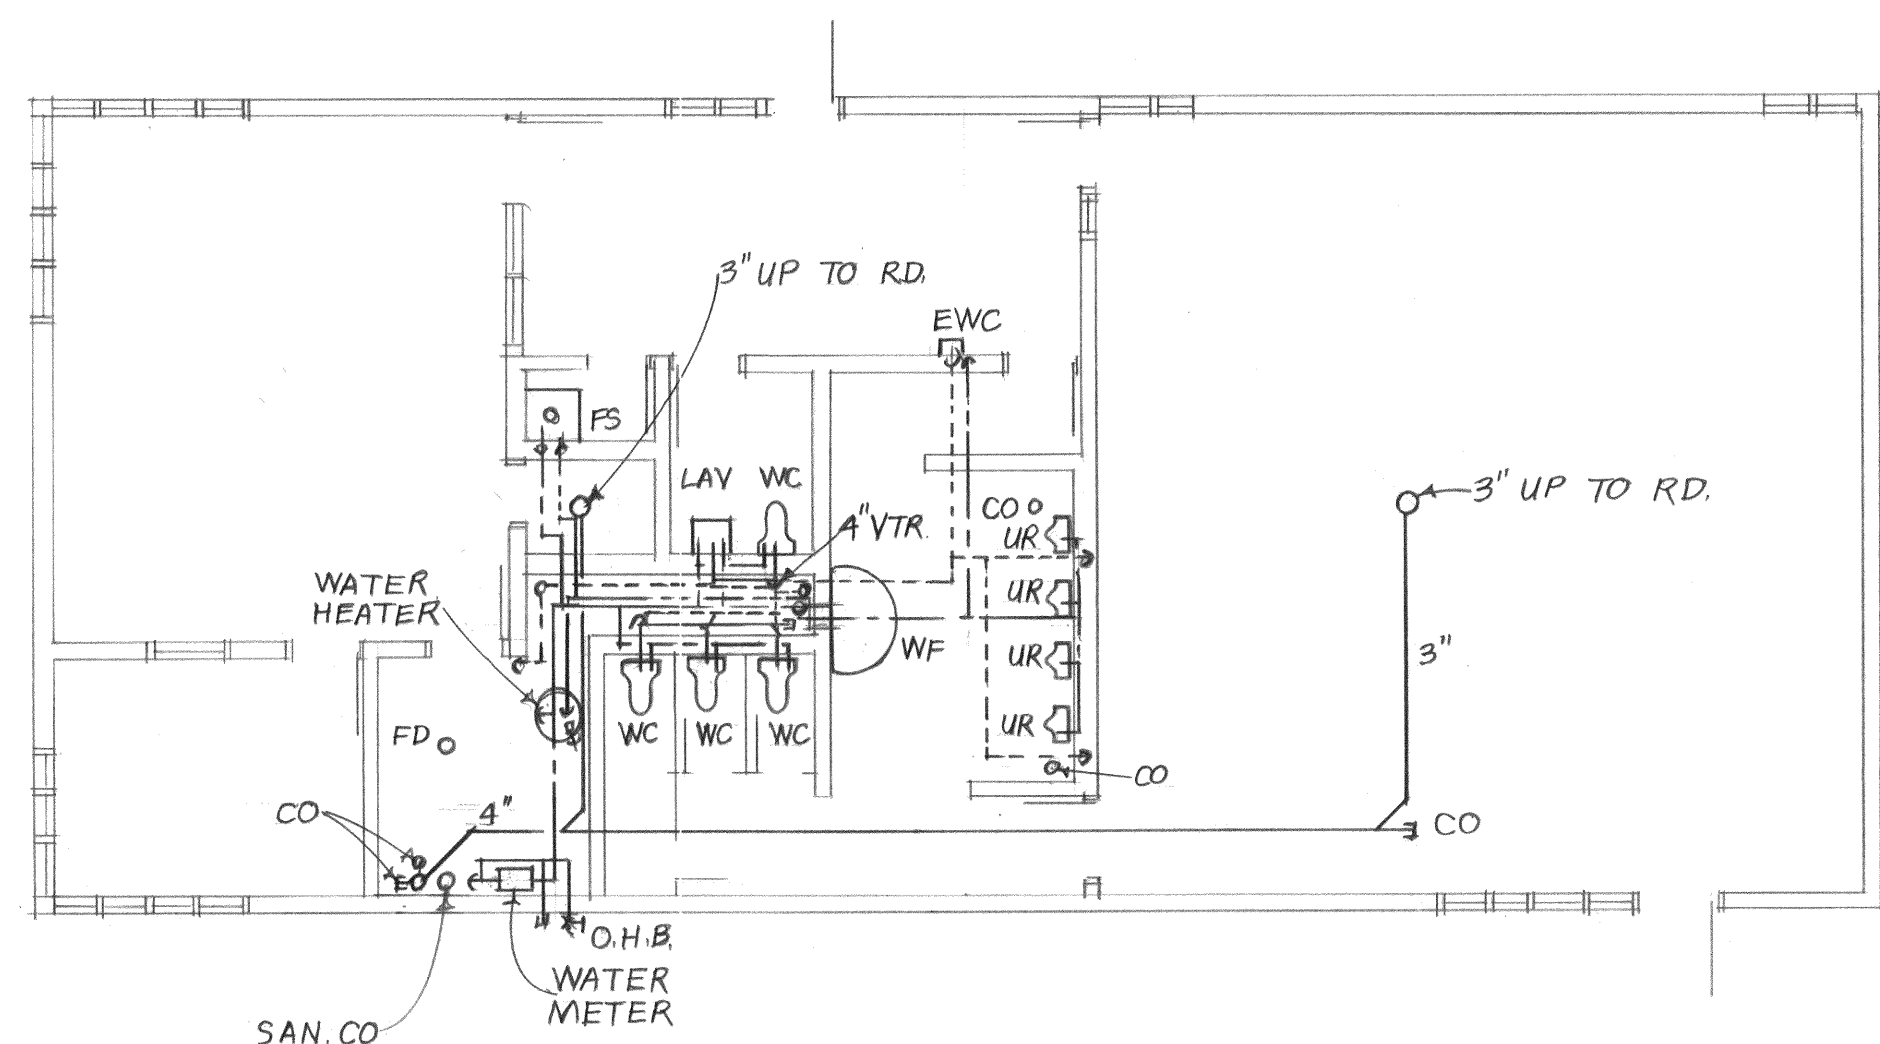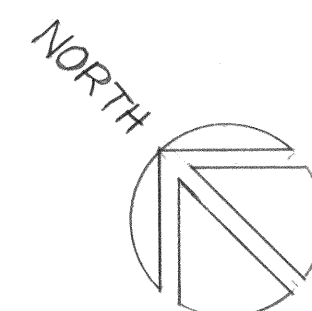

FLOOR PLAN
SCALE: 1/8"=1'-0"

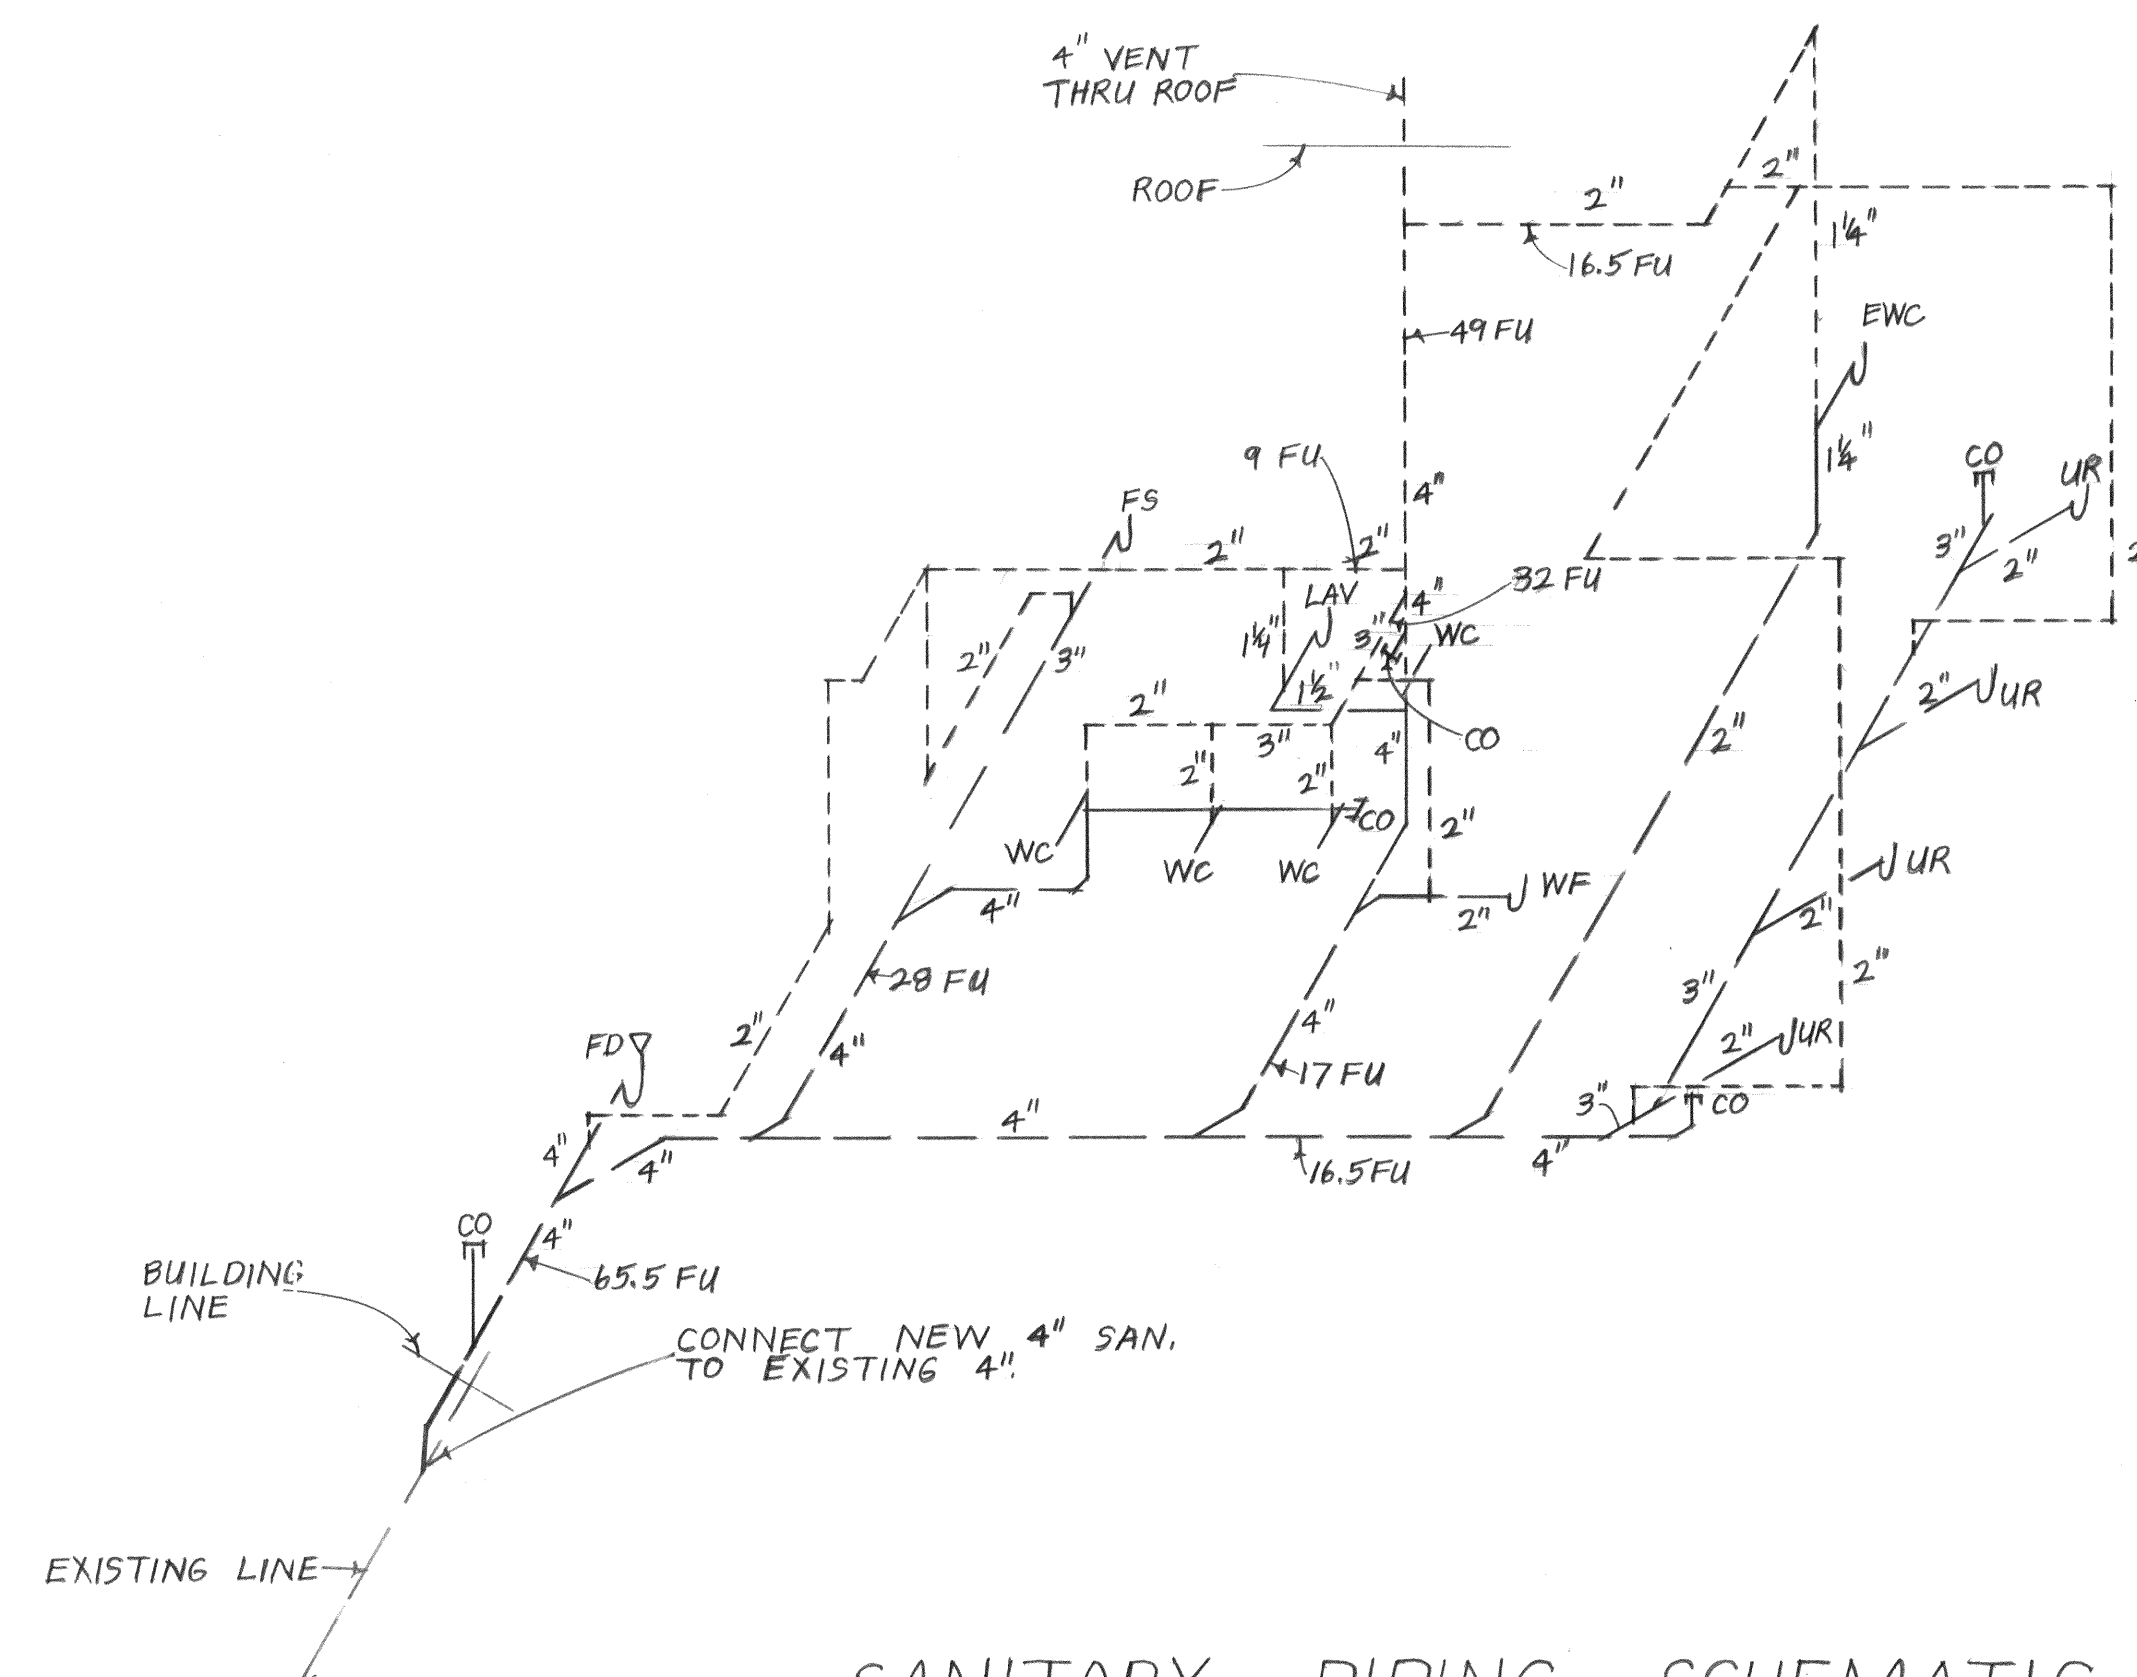



SANITARY PIPING SCHEMATIC
NO SCALE

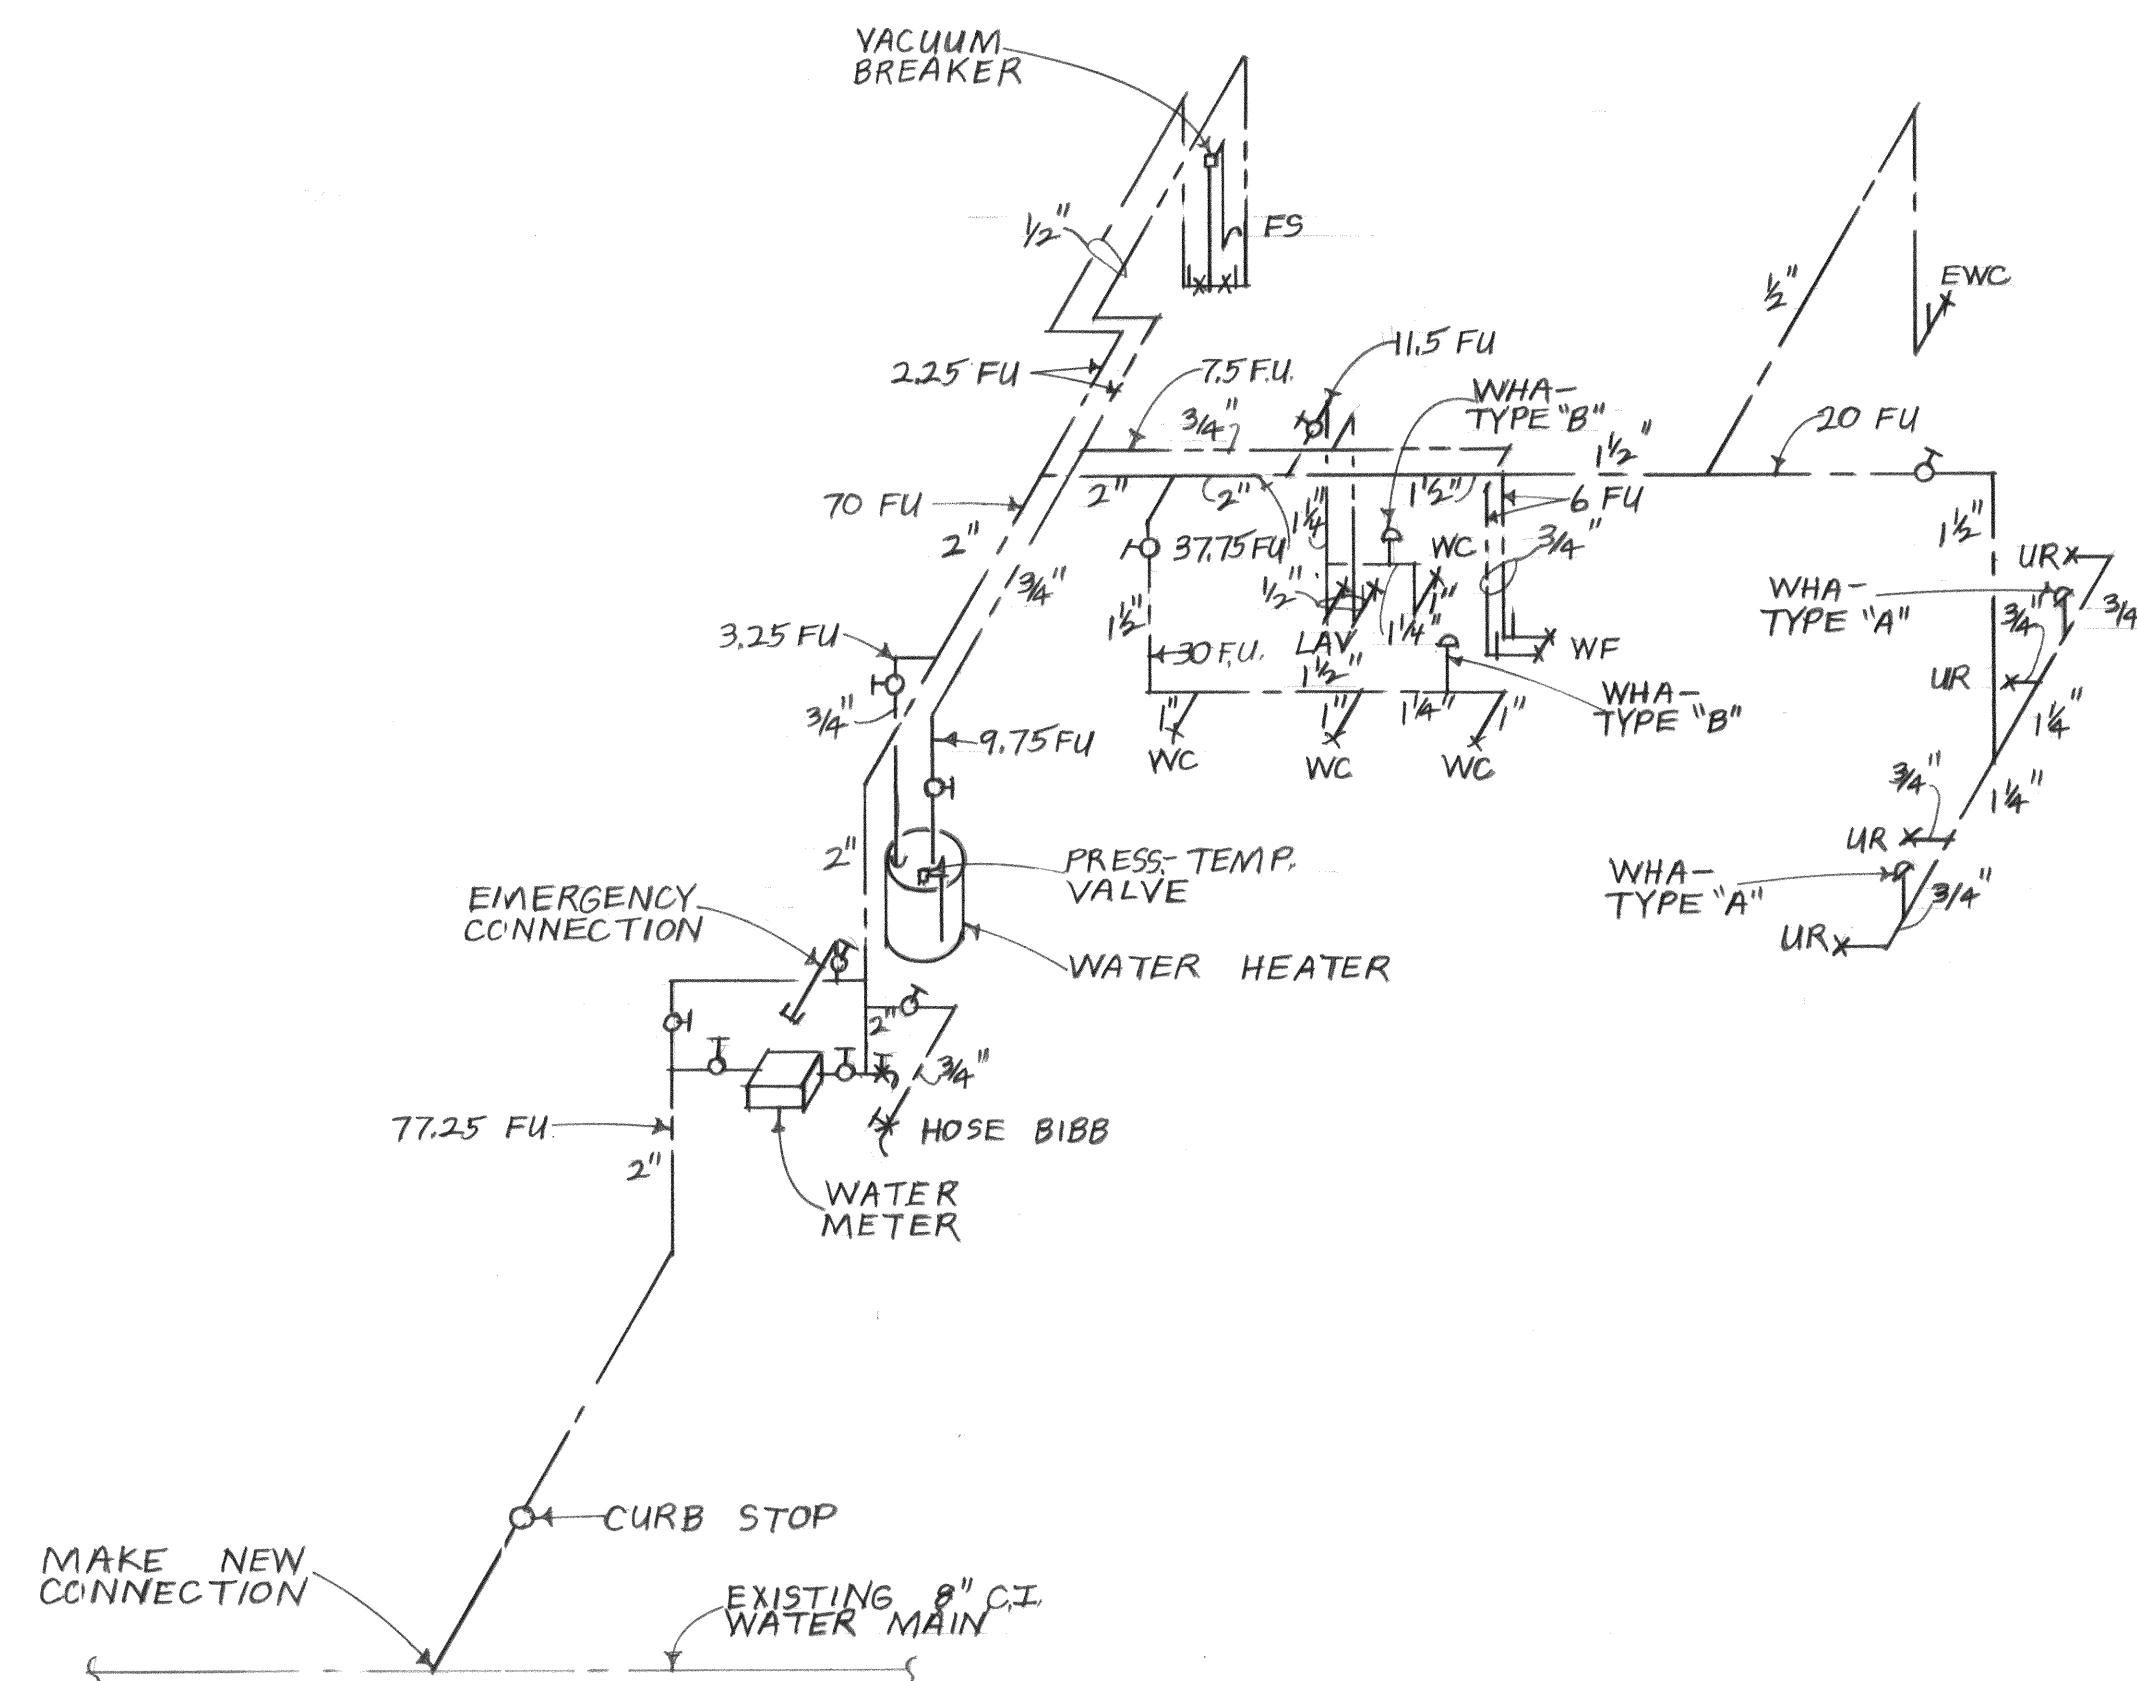


WATER PIPING SCHEMATIC
NO SCALE

LOCATION OF TEMPORARY POWER POLE
ELECTRICAL CONTRACTOR TO REMOVE ALL EXISTING ELECTRICAL EQUIPMENT, LIGHTS, WIRE, CONDUIT, ETC. INSIDE AND OUTSIDE OF EXISTING GARAGE UNLESS SPECIFIED TO BE REUSED.

W. E. POLE

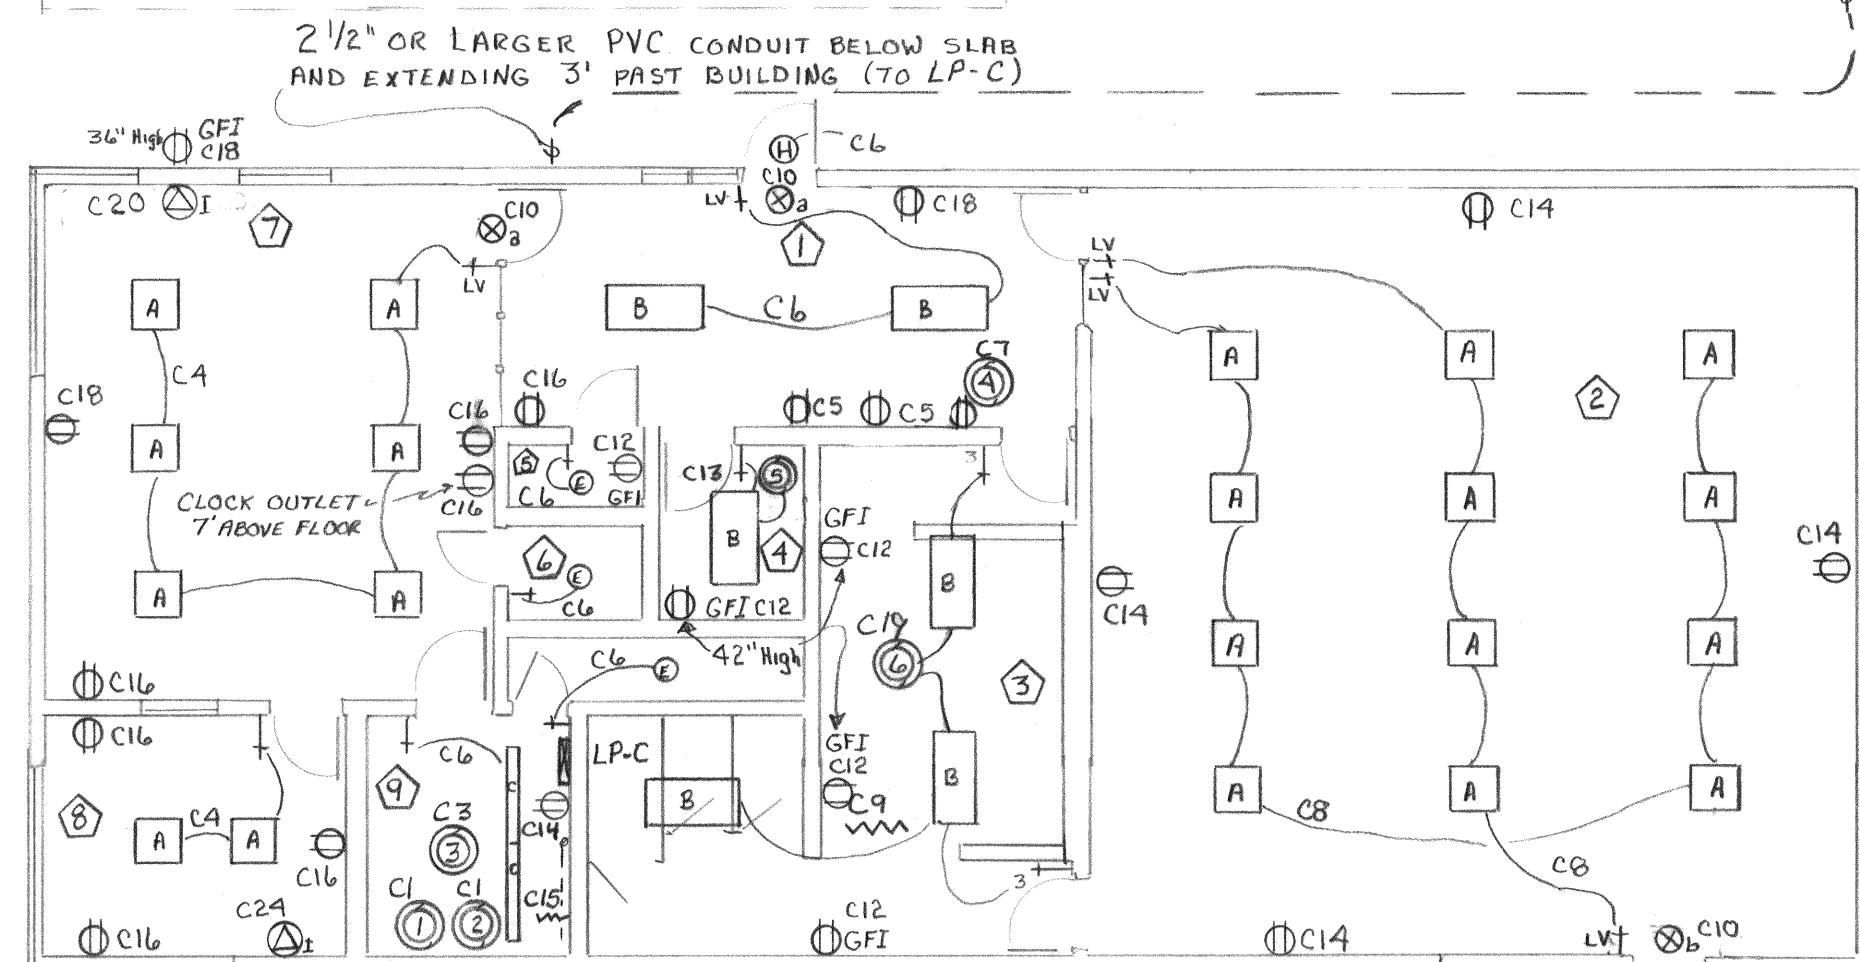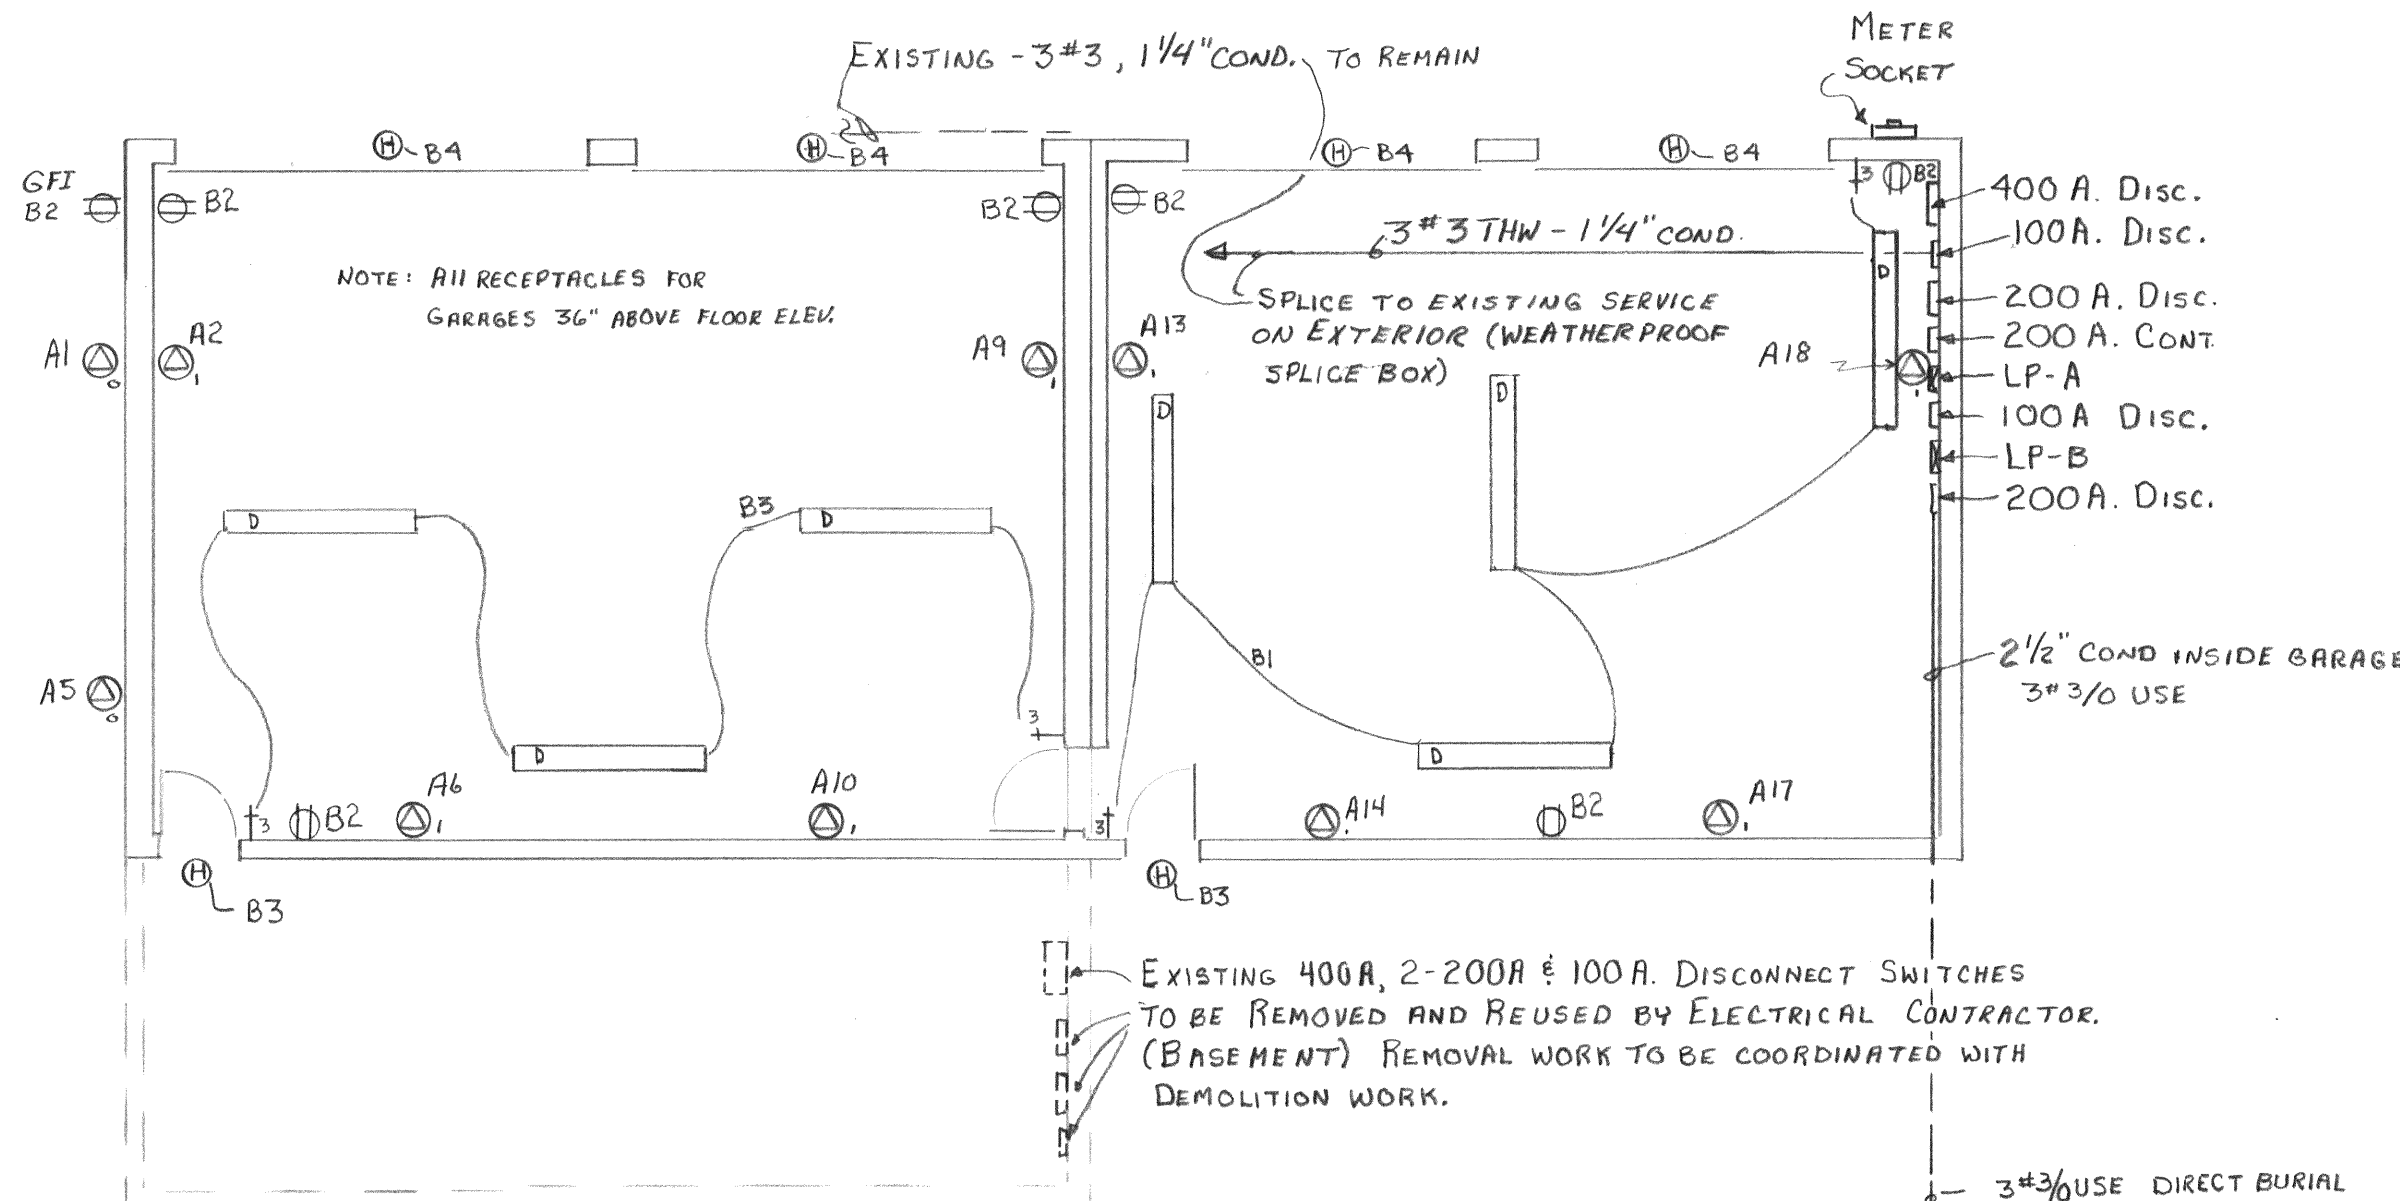


OFFICE
POWER AND LIGHTING PLAN
SCALE 1/8" = 1'-0"

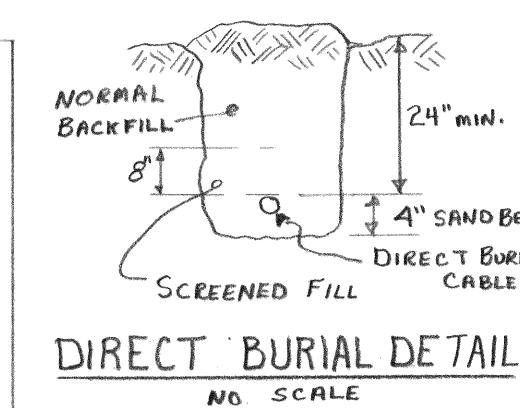

MOTOR SCHEDULE						
MOTOR No.	LOCATION	SERVICE	RATING	VOLTAGE	SUPPLIED BY	REMARKS
1	Rm. 9	COMBUSTION AIR DAMPER	100W	115V	HV CONT	INTERLOCKED W/ BURNER & FURNACE DAMPER
2	"	OUTSIDE AIR DAMPER	100W	"	"	" W/Motor 3
3	"	FURNACE	1/2HP	"	"	INTERLOCKED W/Motor 2
4	Rm. 1	WATER COOLER	5.6FLA	"	PLUMB. CONT.	PLUG CONNECTED
5	Rm. 4	P.R.V.	1/60HP	"	HV CONT.	WIRED WITH LIGHTS
6	Rm. 3	P.R.V.	1/20HP	"	"	" " "

FIXTURE SCHEDULE			
TYPE	DETAIL	DESCRIPTION	MANUFACTURER
A		FLUORESCENT FIXTURE 2'x2' LAY-IN	KEYSTONE CATALOG NO. UJ 240-EXA
B		FLUORESCENT FIXTURE 2'x4' LAY-IN	KEYSTONE CATALOG NO. 2J-240-EXA
C		FLUORESCENT FIXTURE 4'x4' SUSPENDED	KEYSTONE CATALOG NO. CR-240
D		FLUORESCENT FIXTURE 1'x8' SUSPENDED - LOW TEMP. BALLAST	KEYSTONE CATALOG NO. CR-246-HO-B-A
E		INCANDESCENT - 5" DIAM. PORCELAIN	BRYANT CATALOG No. 5288
F		EXIT LIGHT - SPECIAL HANGER FROM SUSP. CEILING	DUAL-LITE TYPE ESQUISITE
G		MERCURY VAPOR, OUTDOOR, 13 1/4" SQUARE, EXTENDED WALL	McPhibben CATALOG No. 22C2144JB-B-VF-FCB - WITH SEPARATE PHOTO CELL OPERATION

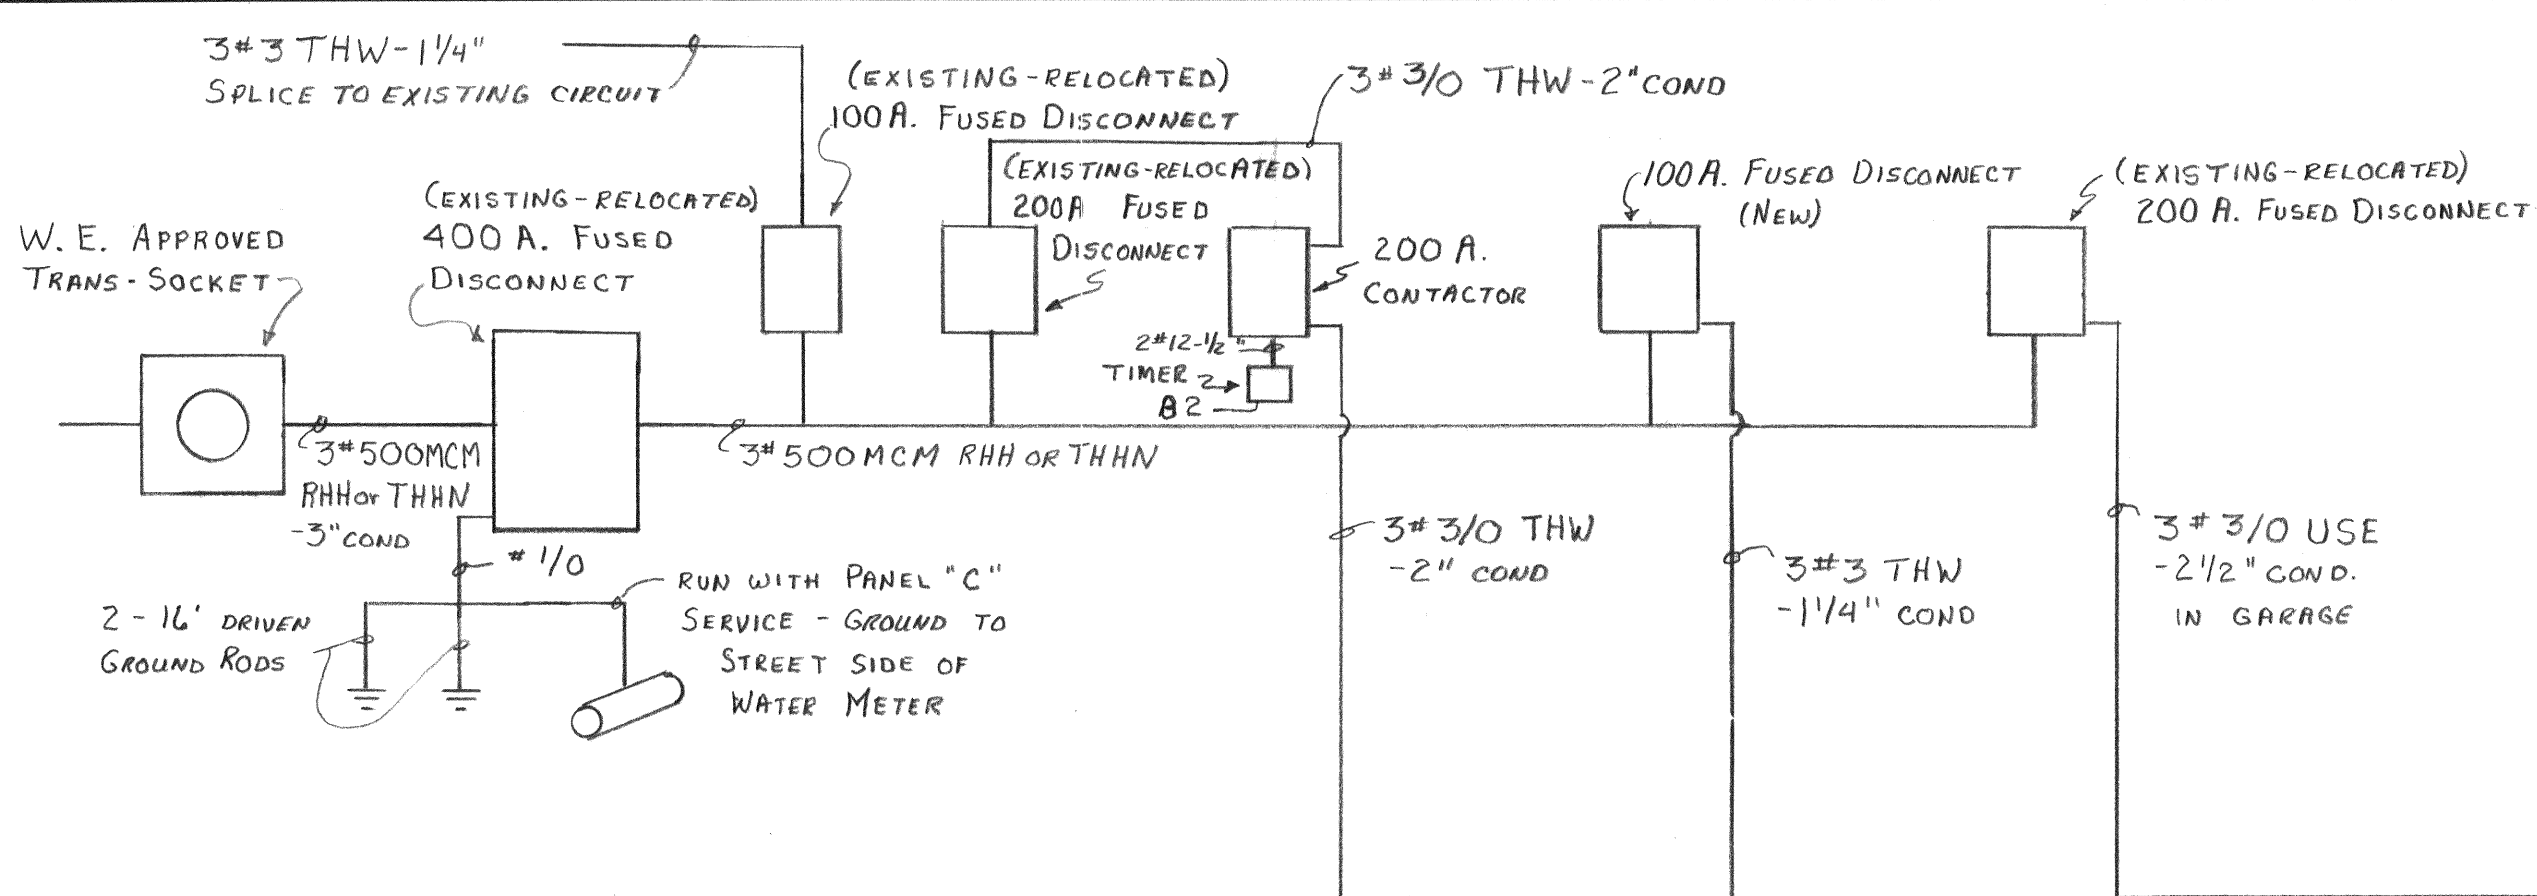

PANEL A			
1	20A	2P	2
2	20A	2P	3
3	20A	2P	4
99	20A	2P	100

PANEL B			
1	15A	2P	1
2	15A	2P	2
3	15A	2P	3
100	15A	2P	100

MOTOR OPERATED DAMPER
2 1/2" TW #12G - 1/2" COND.
MOTOR OPERATED DAMPER
2 1/2" TW #12G - 1/2" COND.
FURNACE BLOWER 1/2 HP
2 1/2" TW #12G - 1/2" COND.
WATER COOLER 5.6FLA
2 1/2" TW #12G - 1/2" COND.
ELECTRIC HEATER 3KW
3 1/2" TW #12G - 1/2" COND.
PRV 1/60 HP, 2 1/2" TW #12G - 1/2" COND.
WATER HEATER 4.5KW
3 1/2" TW #12G - 1/2" COND.
PRV 1/60 HP
2 1/2" TW #12G - 1/2" COND.

PANEL C			
1	15A	2P	1
2	15A	2P	2
3	15A	2P	3
70	15A	2P	70